



UNITED ENGINEERING INC
Mechanical and Electrical Consulting Engineers

3645 Keele St. #105
Toronto, ON, M3J 1M6
Email: info@u-eng.ca
T: (416) 398-1999
F: (416) 398-1933

SITE INSTRUCTION

PROJECT: HAMPTON MANOR
25 BAKER HILL BLVD
STOUFFVILLE, ONTARIO

PROJECT NO: 14-016

CONTRACT: Mechanical

DATE March 15, 2018

SITE INSTRUCTION: M-14

THIS SITE INSTRUCTION IS NOT TO BE CONSTRUED AS A CHANGE IN THE CONTRACT PRICE, BUT IS ISSUED FOR CLARIFICATION ONLY. IF A CHANGE IN CONTRACT PRICE IS PERCEIVED, PROVIDE AN ITEMIZED BREAKDOWN OF ANY EXTRAS OR CREDITS WITHIN SEVEN (7) WORKING DAYS.

Purpose: To suit architecture suite layout changes.

1.0 Reference Drawing M-5, M-9 (Ground Floor - Mechanical) Issued

1.1 Relocated: Plumbing riser #64.

2.0 Reference Drawing M-10, M-14 (2nd Floor - Mechanical) Issued

2.1 Revised: Mechanical layout at suite 211.

3.0 Reference Drawing M-15, M-18, M-19 (3rd, 4th Floor - Mechanical) Issued

3.1 Revised: Mechanical layout at suite 307, 311, 407, 411.

4.0 Reference Drawing M-20, M-23, M-24 (5th Floor - Mechanical) Issued

 
4.1 Revised: Mechanical layout at suite 507, 511.

5.0 Reference Drawing M-25, M-28, M-29 (6th Floor - Mechanical) Issued


5.1 Revised: Mechanical layout at suite 606, 609.

Note: The above will be uploaded to FTP SITE

Project #14-016
Hampton Manor

PREPARED BY: 
Leon Bai
Mechanical Department

ISSUED TO ROYAL PINE HOMES,
Cinzia Caruso, Cinzia@royalpinehomes.com;
Vince Staffieri, vince@royalpinehomes.com
FOR DISTRIBUTION TO ALL AFFECTED PARTIES.

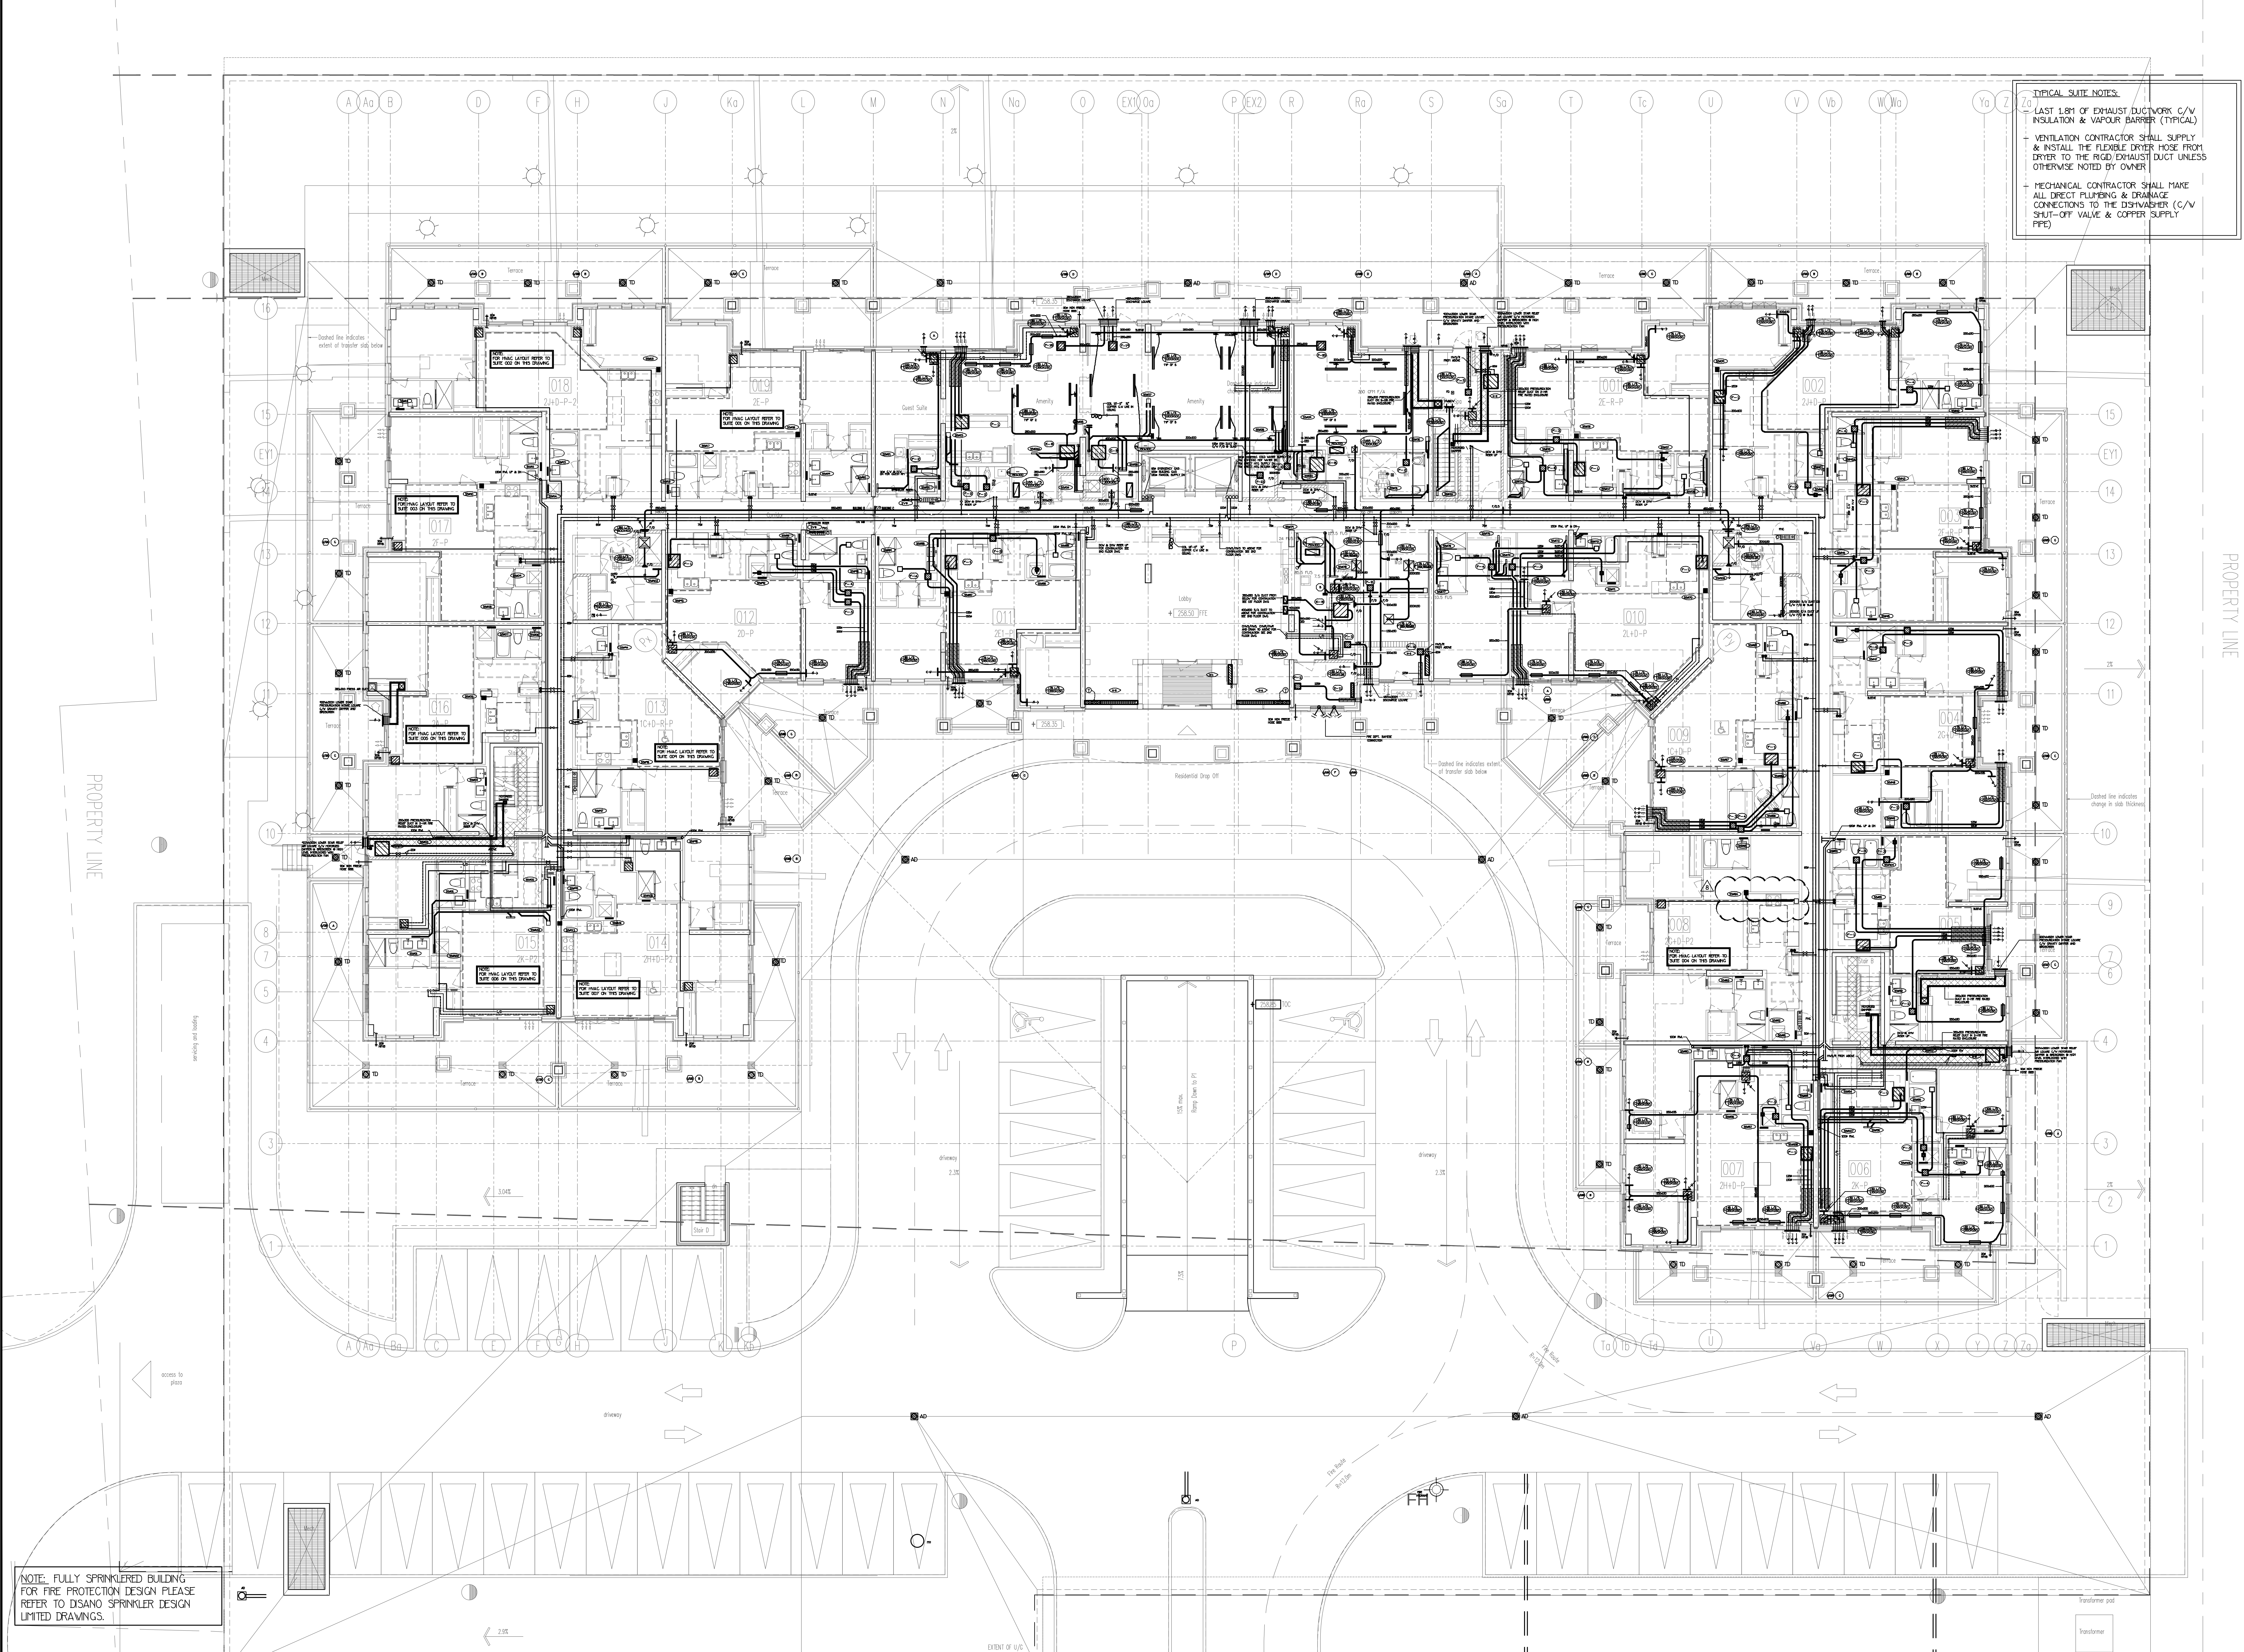

NOTE: FULLY SPRINKLERED BUILDING FOR FIRE PROTECTION DESIGN PLEASE REFER TO DISANO SPRINKLER DESIGN LIMITED DRAWINGS.

NO.	BY	DESCRIPTION	DATE
8	LB	REVISED AS PER SITE INSTRUCTION N-14	MAR/14/2018
7	LB	REVISED AS PER SITE INSTRUCTION N-10	OCT/31/2017
6	LB	REVISED AS PER SITE INSTRUCTION N-7	SEP/11/2017
5	LB	REVISED AS PER SITE INSTRUCTION N-5 ISSUED FOR CONSTRUCTION	AUG/09/2017
4	LB	PROGRESS FOR CONSTRUCTION	JUL/18/2017
3	OP	REVISED AS PER SITE INSTRUCTION N-3	MAR/02/2017
2	LH	ISSUED FOR PERMIT	DEC/28/2016
1	LH	ISSUED FOR TENDER	MAR/21/2016


REVISIONS

This drawing, is an instrument of service, is provided by and is the property of United Engineering Inc. The contractor must verify and accept responsibility for all dimensions and conditions on site and must notify United Engineering Inc. of any discrepancy before proceeding.

United Engineering Inc. is not responsible for the accuracy of Architectural, structural, interior design, etc. on this drawing.


Refer to the appropriate trade drawings before proceeding with any work. Installation must conform to all applicable codes and requirements of the authorities having jurisdiction.

This drawing is not to be scaled, all symbols are graphic representations only.

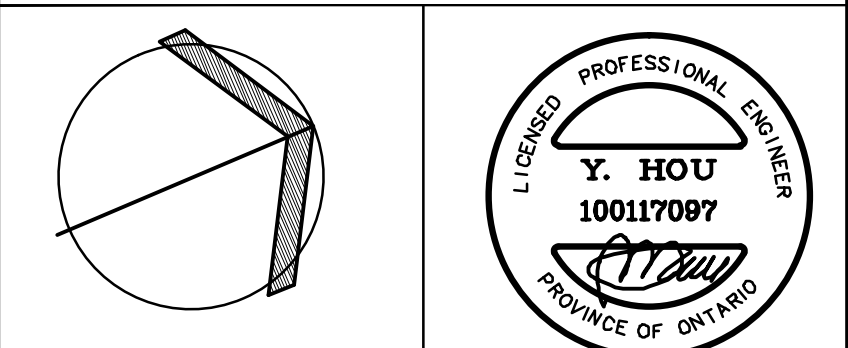

United Engineering Inc.
Mechanical Electrical Consulting Engineers
3645 Keele Street, Suite 105,
Toronto, Ontario, M3J 1W6
Tel: (416) 598 1999; Fax: (416) 598 1933

TITLE 1ST FLOOR LEVEL MECHANICAL			
PROJECT 25 BAKER HILL BLVD. ROYAL PINE HOMES			
STOUFFVILLE, ONTARIO		PROPOSED RESIDENTIAL DEVELOPMENT	
DRAWN GC	CHECKED BT	SCALE 1:100	DRAWING M-5
DATE JUNE 2015	PROJECT 14-016	OF 42	

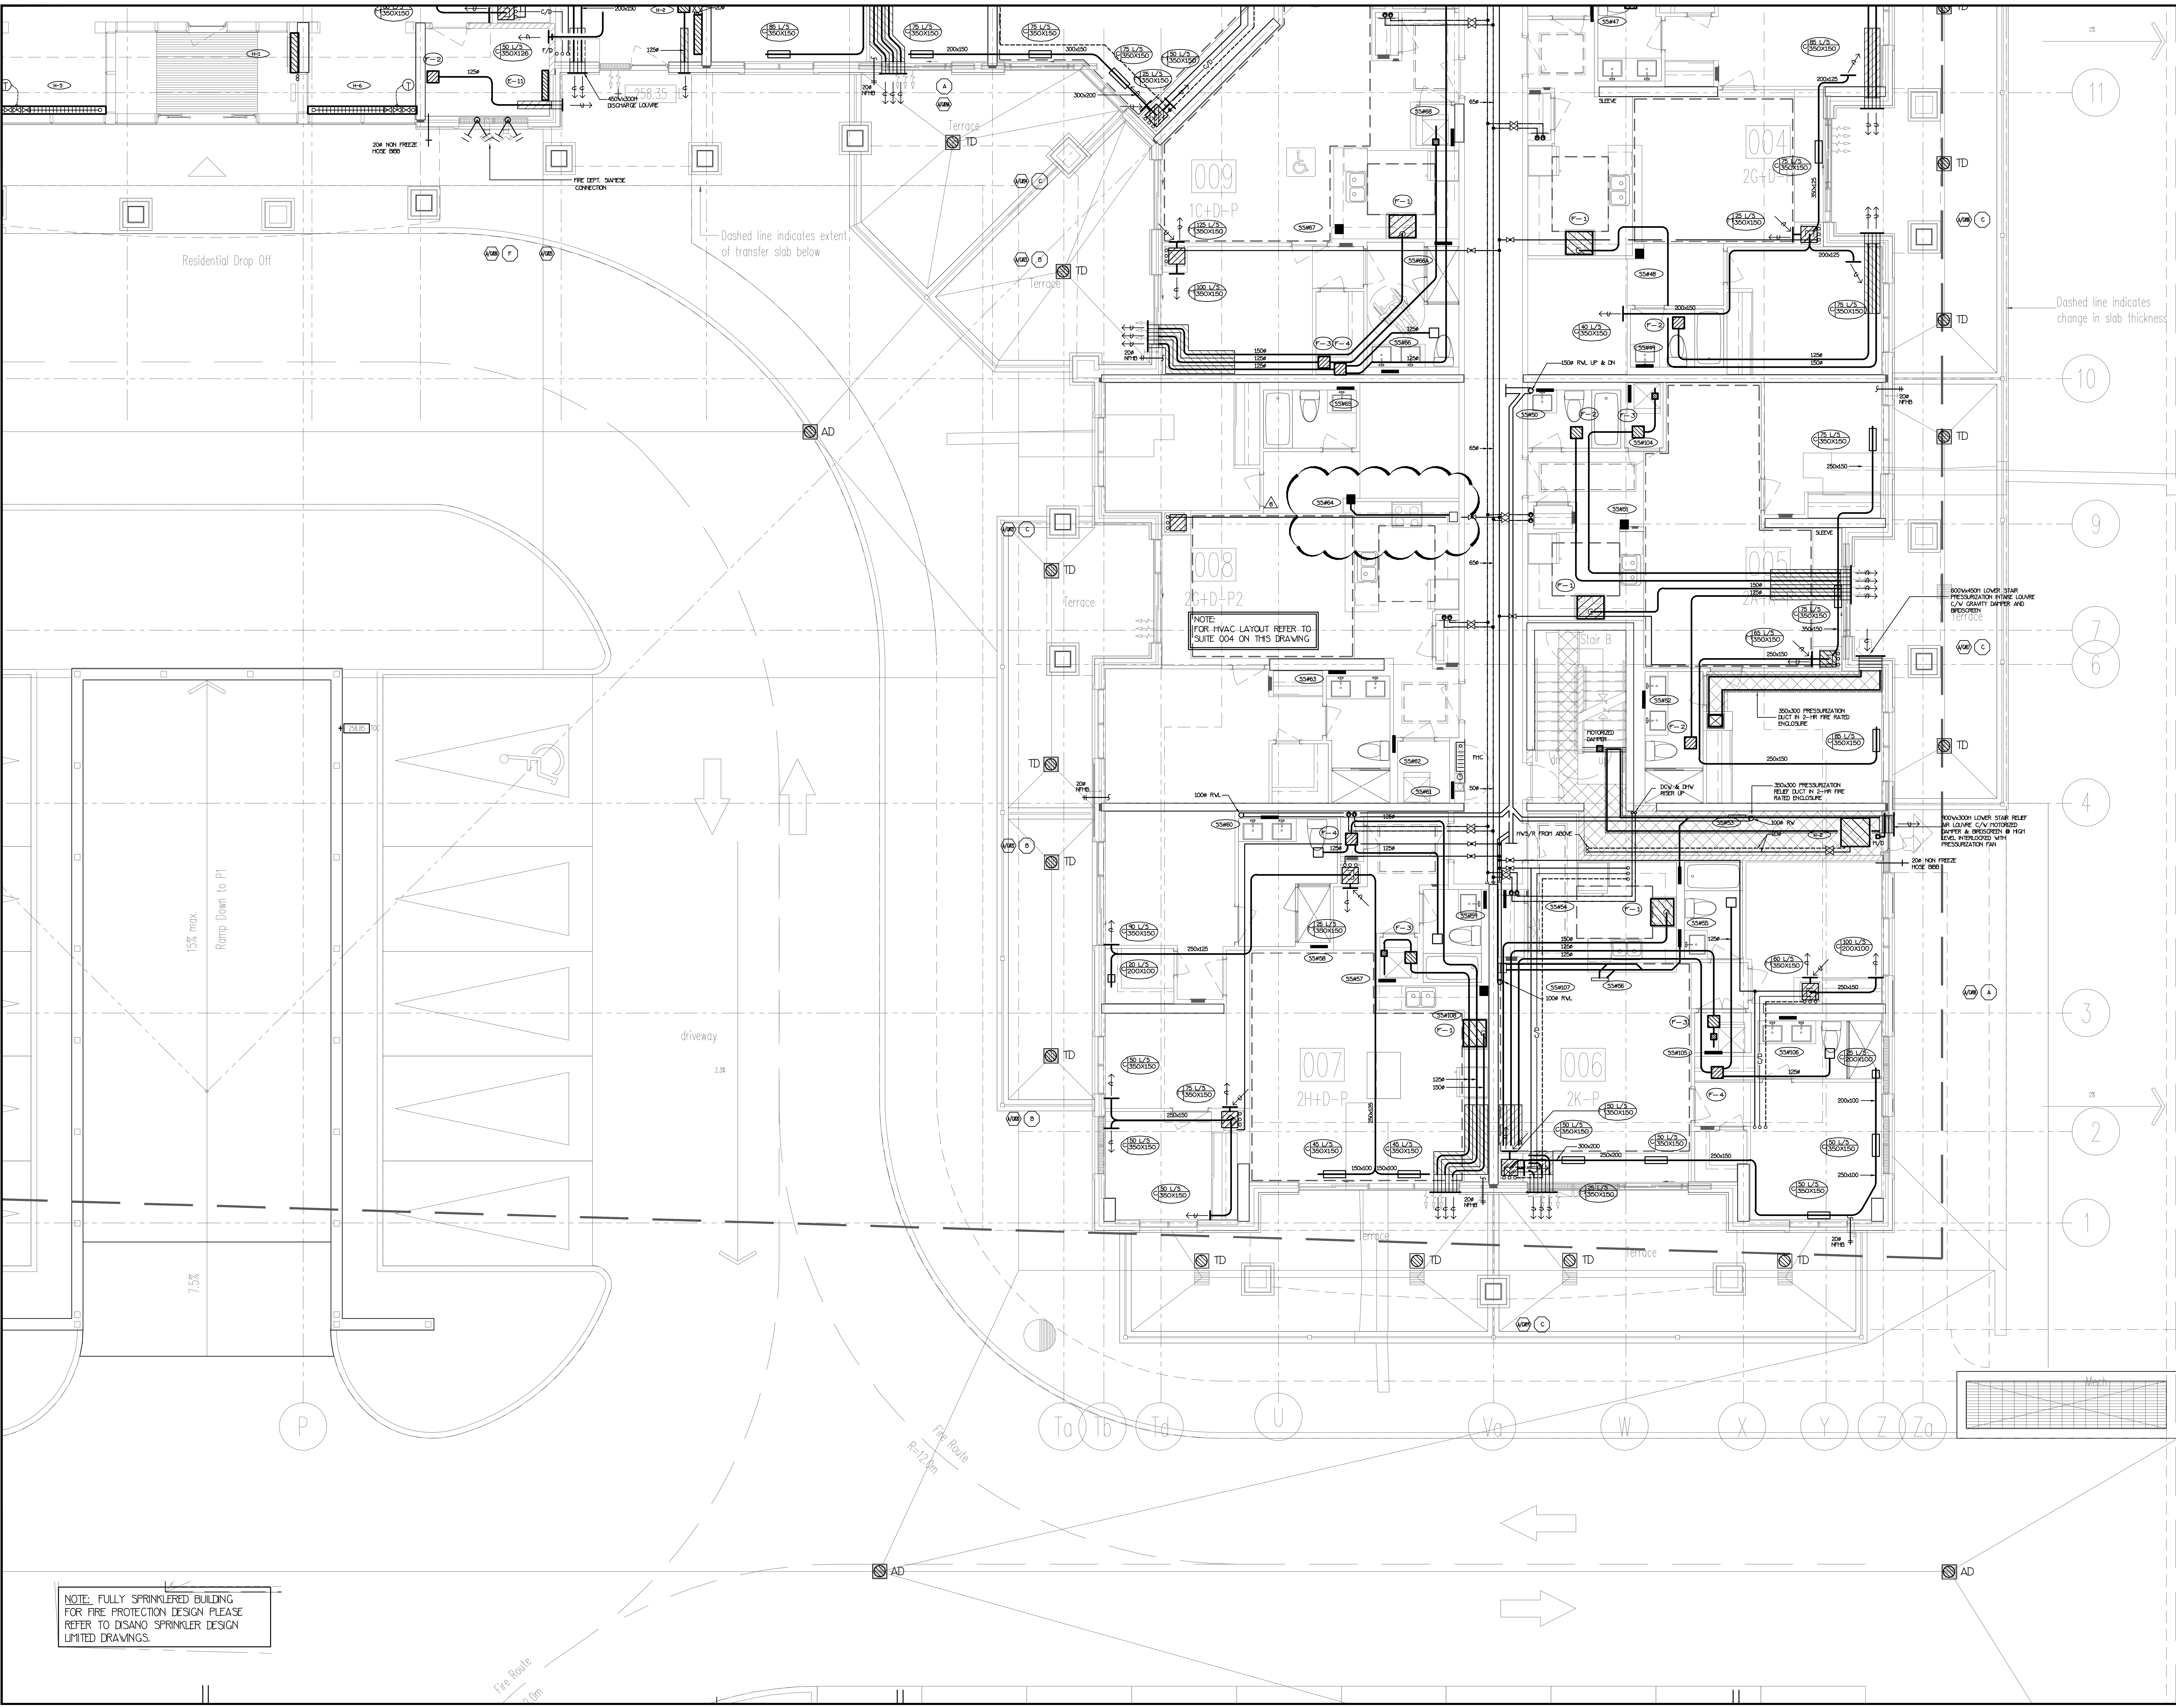

NO.	BY	DESCRIPTION	DATE
7	LB	REVISED AS PER SITE INSTRUCTION P-14	MAR/14/2018
6	LB	REVISED AS PER SITE INSTRUCTION P-7	SEP/11/2017
5	LB	REVISED AS PER SITE INSTRUCTION P-5	AUG/09/2017
4	LB	PROGRESS FOR CONSTRUCTION	JUL/18/2017
3	OP	REVISED AS PER SITE INSTRUCTION P-3	MAR/02/2017
2	U1	ISSUED FOR PERMIT	DEC/28/2016
1	U1	ISSUED FOR TENDER	MAR/21/2016


REVISIONS

This drawing, is an instrument of service, is provided by and is the property of United Engineering Inc.. The contractor must verify and accept responsibility for all dimensions and conditions on site and must notify United Engineering Inc. of any discrepancy before proceeding.

United Engineering Inc. is not responsible for the accuracy of Architectural, structural, interior design, etc. on this drawing.


Refer to the appropriate trade drawings before proceeding with any work. Installation must conform to all applicable codes and requirements of the authorities having jurisdiction.

This drawing is not to be scaled, all symbols are graphic representations only.

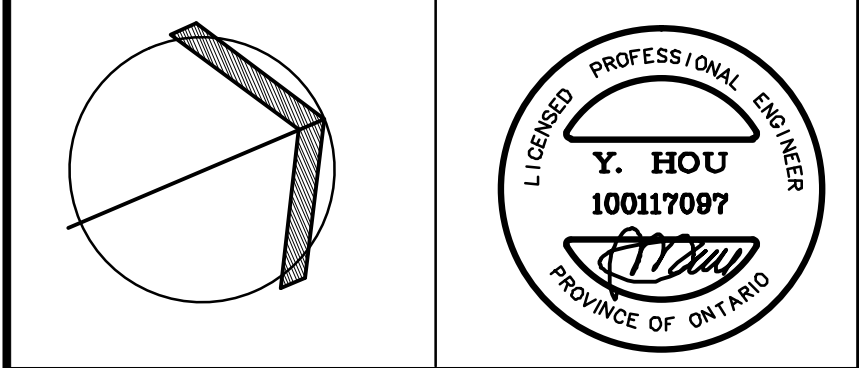

United Engineering Inc.
Mechanical/Electrical Consulting Engineers
3445 Heale Street, Suite 105,
Toronto, Ontario, M3J 1M6
Tel: (416) 598 1999; Fax: (416) 598 1935

TITLE 1ST FLOOR LEVEL MECHANICAL			
PROJECT 25 BAKER HILL BLVD. ROYAL PINE HOMES			
STOUFFVILLE, ONTARIO		PROPOSED RESIDENTIAL DEVELOPMENT	
DRAWN GC	CHECKED BT	SCALE 1:50	DRAWING M-9
DATE JUNE 2015	PROJECT 14-016	OF 42	

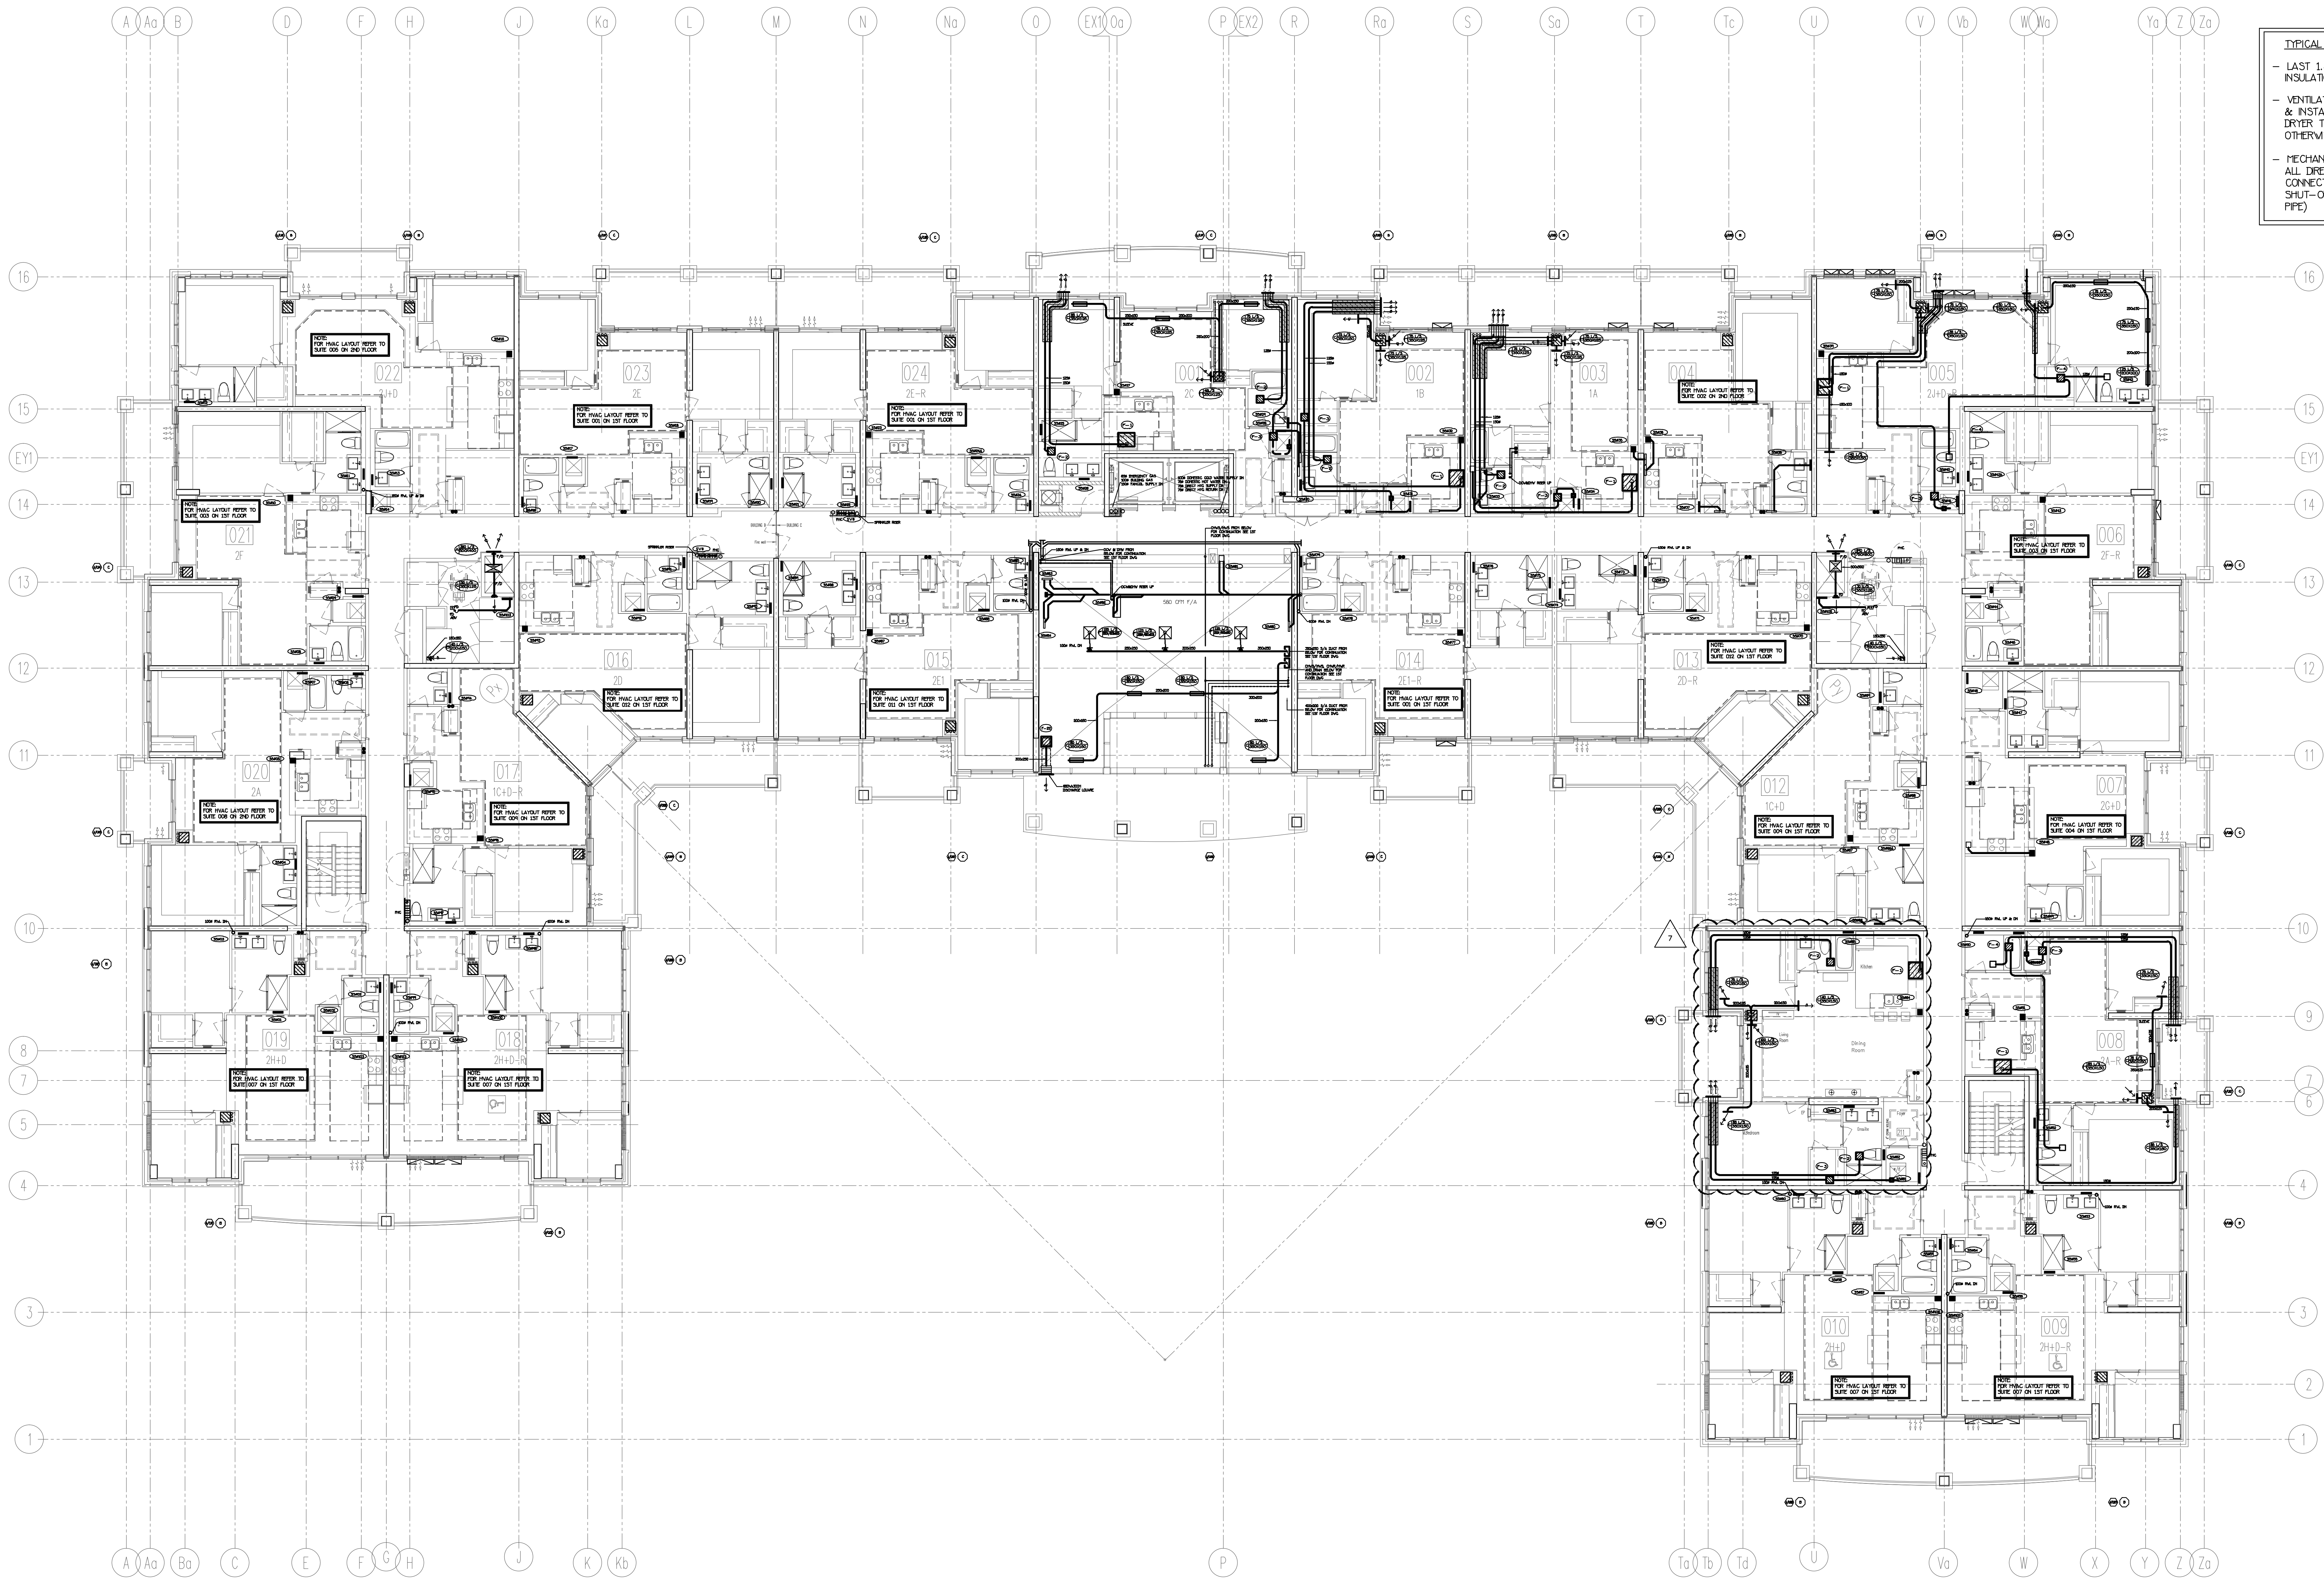


TYPICAL SUITE NOTES:

- LAST 1.8M OF EXHAUST DUCTWORK C/V INSULATION & VAPOUR BARRIER (TYPICAL)
- VENTILATION CONTRACTOR SHALL SUPPLY & INSTALL THE FLEXIBLE DRYER HOSE FROM DRYER TO THE RIGID EXHAUST DUCT UNLESS OTHERWISE NOTED BY OWNER
- MECHANICAL CONTRACTOR SHALL MAKE ALL DIRECT PLUMBING & DRAINAGE CONNECTIONS TO THE DISHWASHER (C/V SHUT-OFF VALVE & COPPER SUPPLY PIPE)

NOTE: FULLY SPRINKLERED BUILDING FOR FIRE PROTECTION DESIGN PLEASE REFER TO DESIGNED SPRINKLER DESIGN UNITED DRAWINGS.

NO.	BY	DESCRIPTION	DATE
7	LB	REVISED AS PER SITE INSTRUCTION T1-14	MAR/14/2018
6	LB	REVISED AS PER SITE INSTRUCTION T1-10	OCT/31/2017
5	LB	REVISED AS PER SITE INSTRUCTION T1-5 ISSUED FOR CONSTRUCTION	AUG/09/2017
4	LB	PROGRESS FOR CONSTRUCTION	JUL/18/2017
3	LB	ISSUED AS PER SITE INSTRUCTION T1-4	MAY/16/2017
2	LYI	ISSUED FOR PERMIT	DEC/28/2016
1	LYI	ISSUED FOR TENDER	MAR/23/2016

This drawing, is an instrument of service, is provided by and is the property of United Engineering Inc. The contractor must verify and accept responsibility for all dimensions and conditions on site and must notify United Engineering Inc. of any discrepancy before proceeding. United Engineering Inc. is not responsible for the accuracy of Architectural, structural, interior design, etc. on this drawing. Refer to the appropriate trade drawings before proceeding with any work. Installation must conform to all applicable codes and requirements of the authorities having jurisdiction. This drawing is not to be scaled, all symbols are graphic representations only.

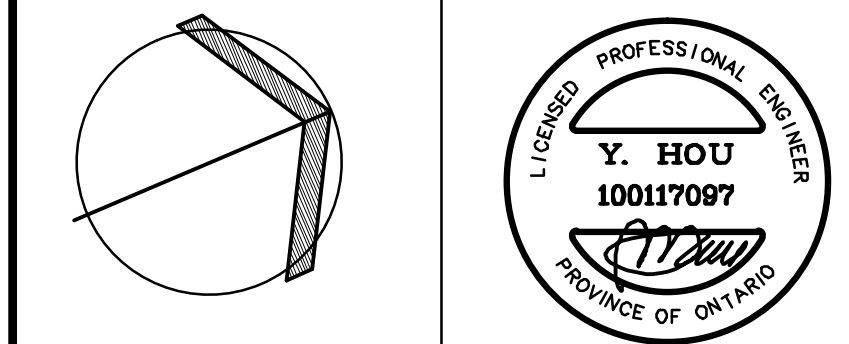


United Engineering Inc.
Mechanical Electrical Consulting Engineers
3045 Keele Street, Suite 105,
Toronto, Ontario, M3J 1M6
Tel: (416) 398 1999, Fax: (416) 398 1933

TITLE 2ND FLOORS PLAN MECHANICAL			
PROJECT 25 BAKER HILL BLVD. ROYAL PINE HOMES			
STOUFFVILLE, ONTARIO PROPOSED RESIDENTIAL DEVELOPMENT			
DRAWN GC JUNE 2015	CHECKED ST 14-016	SCALE 1:100	DRAWING M-10 OF 42



		42
--	--	----

This drawing, is an instrument of service, is provided by and is the property of United Engineering Inc. The contractor must verify and accept responsibility for all dimensions and conditions on site and must notify United Engineering Inc. of any discrepancy before proceeding. United Engineering Inc. is not responsible for the accuracy of Architectural, structural, interior design, etc. on this drawing. Refer to the appropriate trade drawings before proceeding with any work. Installation must conform to all applicable codes and requirements of the authorities having jurisdiction. This drawing is not to be scaled, all symbols are graphic representations only.

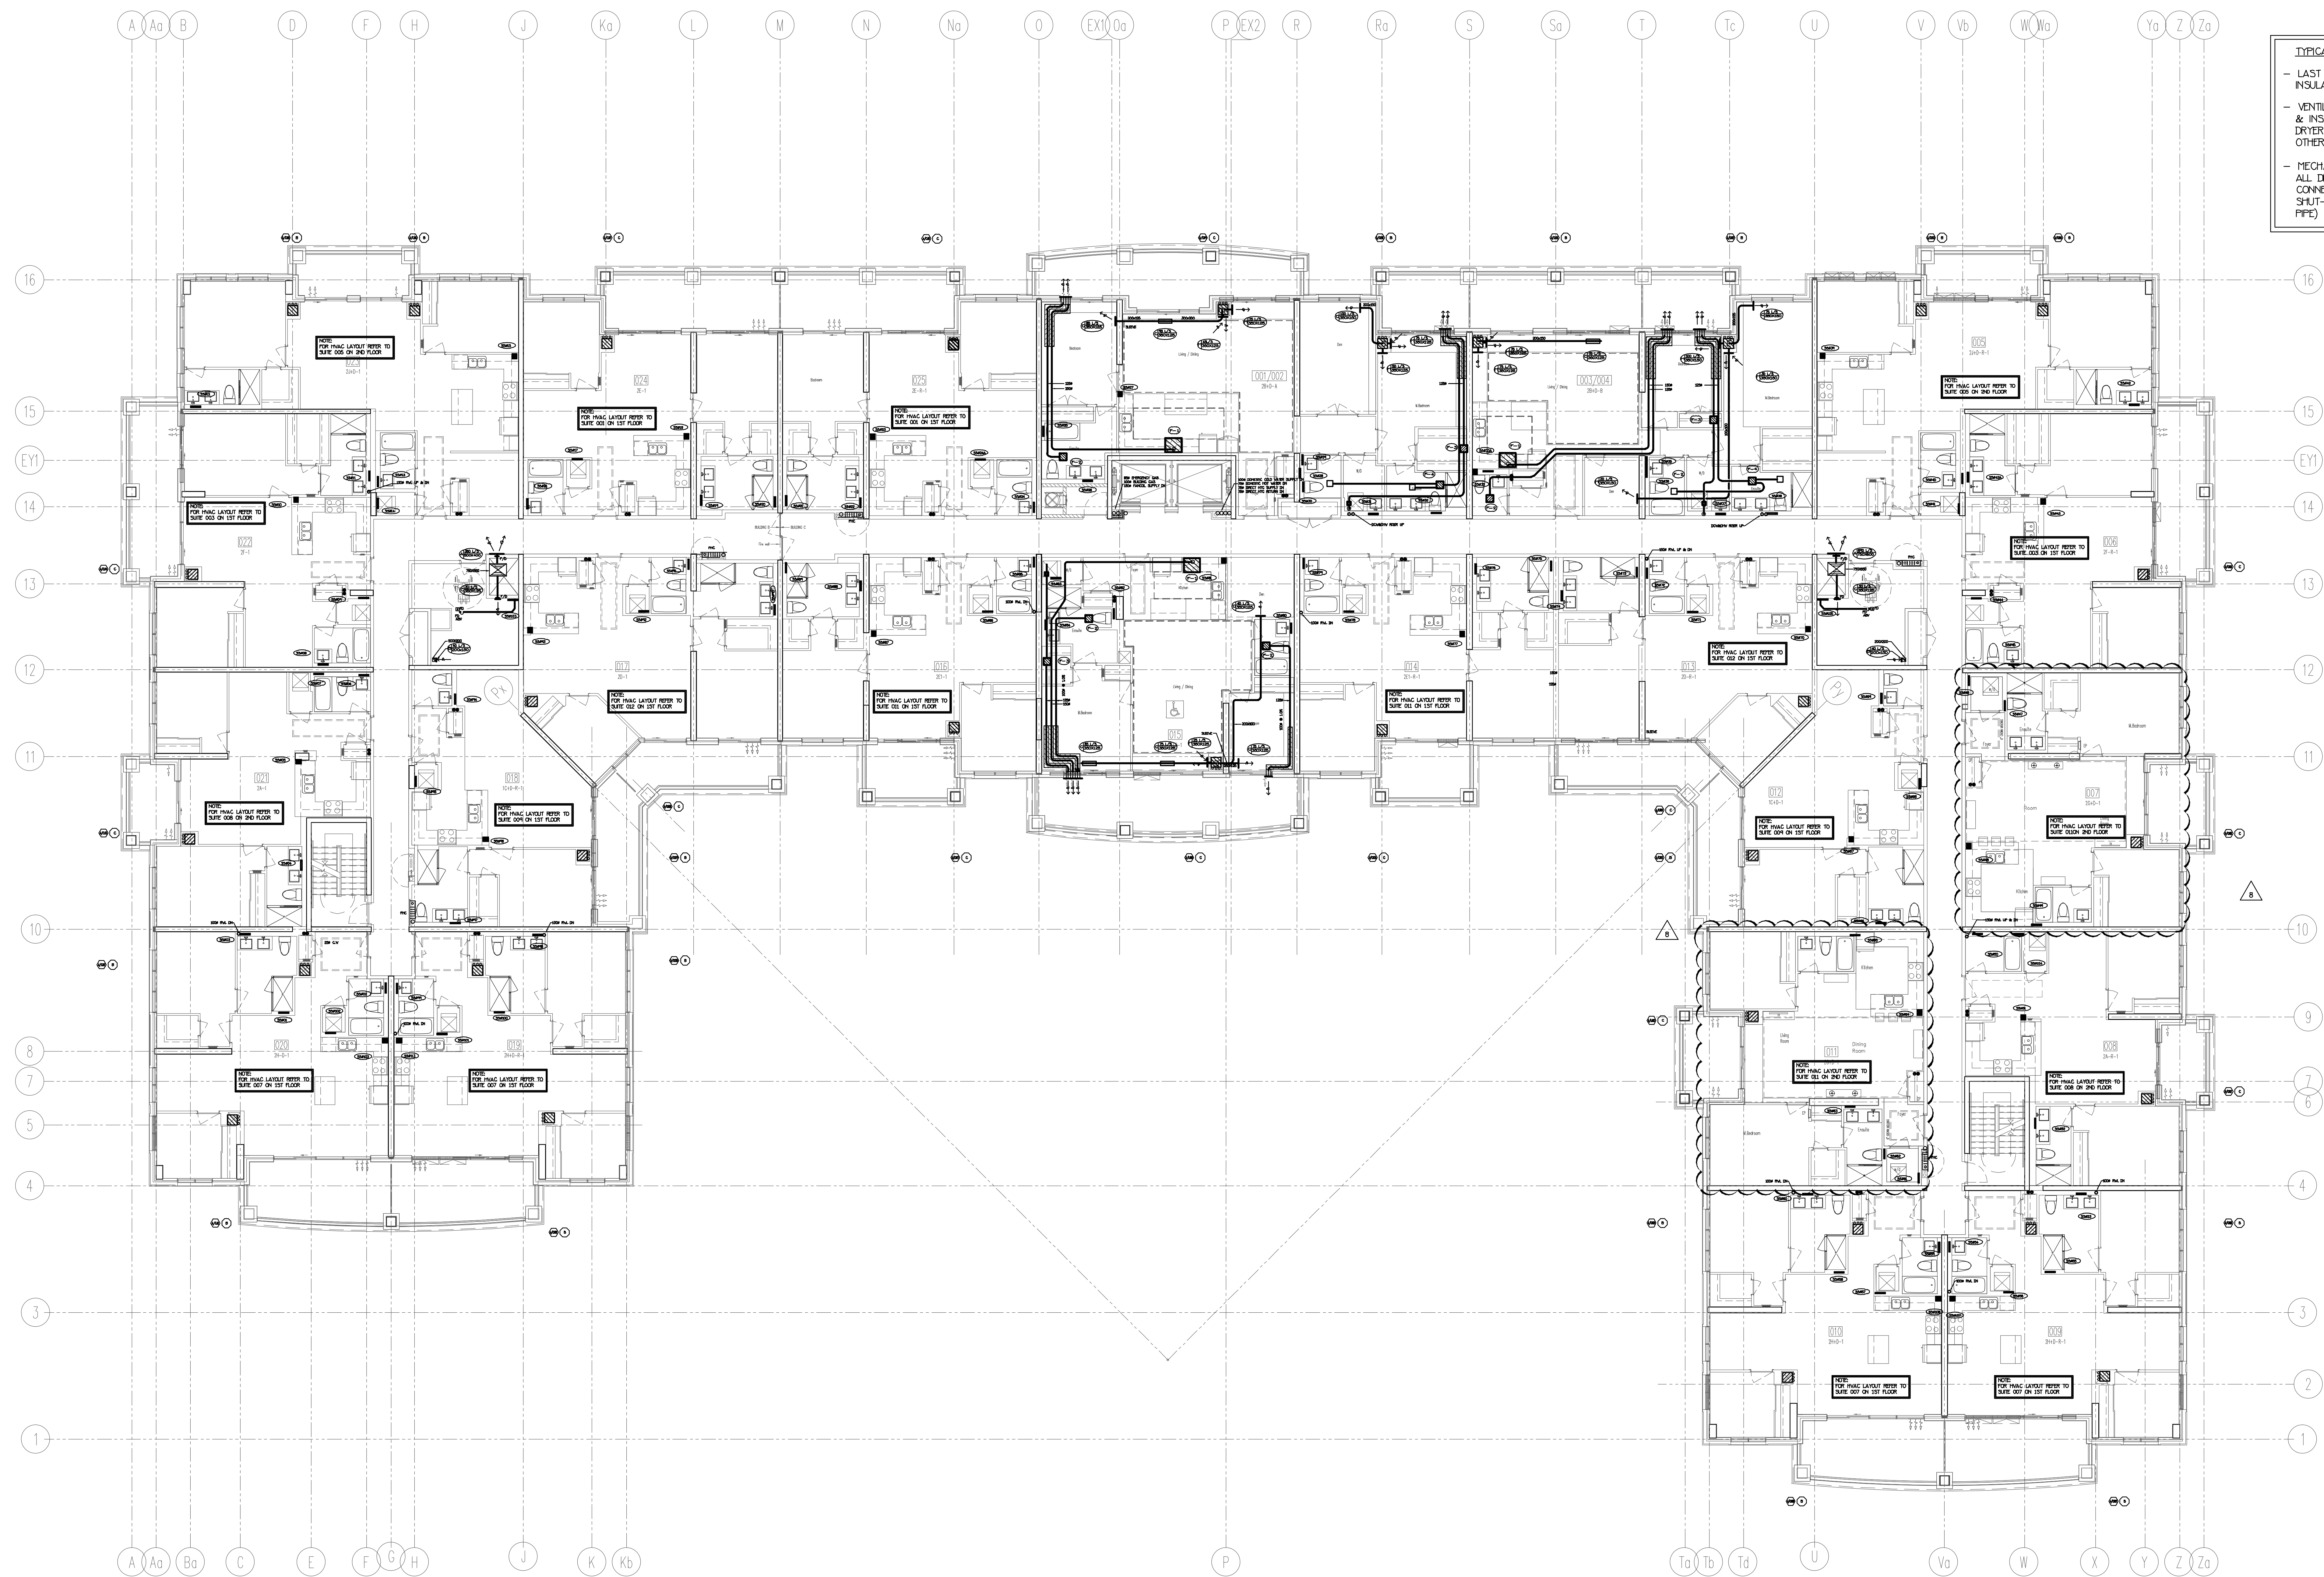


TYPICAL SUITE NOTES:

- LAST 1.8M OF EXHAUST DUCTWORK C/V INSULATION & VAPOUR BARRIER (TYPICAL)
- VENTILATION CONTRACTOR SHALL SUPPLY & INSTALL THE FLEXIBLE DRYER HOSE FROM DRYER TO THE RIGID EXHAUST DUCT UNLESS OTHERWISE NOTED BY OWNER
- MECHANICAL CONTRACTOR SHALL MAKE ALL DIRECT PLUMBING & DRAINAGE CONNECTIONS TO THE DISHWASHER (C/V SHUT-OFF VALVE & COPPER SUPPLY PIPE)

NO.	BY	DESCRIPTION	DATE
8	LB	REVISED AS PER SITE INSTRUCTION T1-14	MAR/14/2018
7	LB	REVISED AS PER SITE INSTRUCTION T1-10	OCT/31/2017
6	LB	REVISED AS PER SITE INSTRUCTION T1-5	AUG/25/2017
5	LB	REVISED AS PER SITE INSTRUCTION T1-5 ISSUED FOR CONSTRUCTION	AUG/09/2017
4	LB	PROGRESS FOR CONSTRUCTION	JUL/18/2017
3	LB	ISSUED AS PER SITE INSTRUCTION T1-4	MAY/18/2017
2	LM	ISSUED FOR PERMIT	DEC/28/2016
1	LM	ISSUED FOR TENDER	MAR/23/2016


This drawing, is an instrument of service, is provided by and is the property of United Engineering Inc. The contractor must verify and accept responsibility for all dimensions and conditions on site and must notify United Engineering Inc. of any discrepancy before proceeding. United Engineering Inc. is not responsible for the accuracy of Architectural, structural, interior design, etc. on this drawing. Refer to the appropriate trade drawings before proceeding with any work. Installation must conform to all applicable codes and requirements of the authorities having jurisdiction. This drawing is not to be scaled, all symbols are graphic representations only.

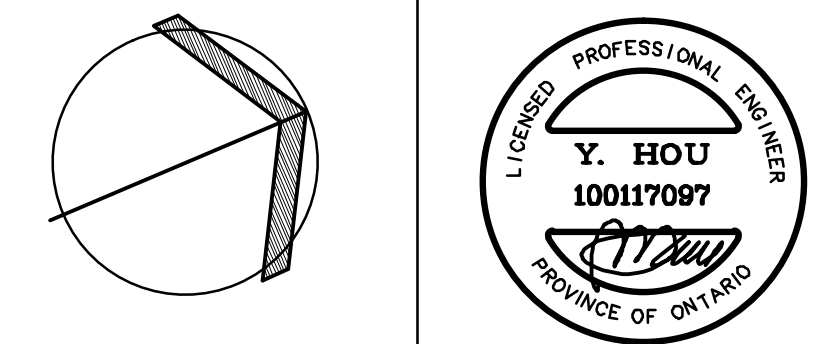

United Engineering Inc.
Mechanical Electrical Consulting Engineers
3045 Keele Street Suite 105,
Toronto, Ontario, M3J 1M6
Tel: (416) 398 1999, Fax: (416) 398 1933

TITLE PART 3RD AND 4TH FLOORS MECHANICAL			
PROJECT 25 BAKER HILL BLVD. ROYAL PINE HOMES			
STOUFFVILLE, ONTARIO PROPOSED RESIDENTIAL DEVELOPMENT			
DRAWN	GC	CHECKED	BT
DATE	JUNE 2015	PROJECT	14-016
		DRAWING	M-15
		OF	42

- LAST 1.8M OF EXHAUST DUCTWORK C/
INSULATION & VAPOUR BARRIER (TYPICAL)
- VENTILATION CONTRACTOR SHALL SUPPLY
& INSTALL THE FLEXIBLE DRYER HOSE FROM
DRYER TO THE RIGID EXHAUST DUCT UNLESS
OTHERWISE NOTED BY OWNER
- MECHANICAL CONTRACTOR SHALL MAKE
ALL DIRECT PLUMBING & DRAINAGE
CONNECTIONS TO THE DISHWASHER (C/
SHUT-OFF VALVE & COPPER SUPPLY
PIPE)

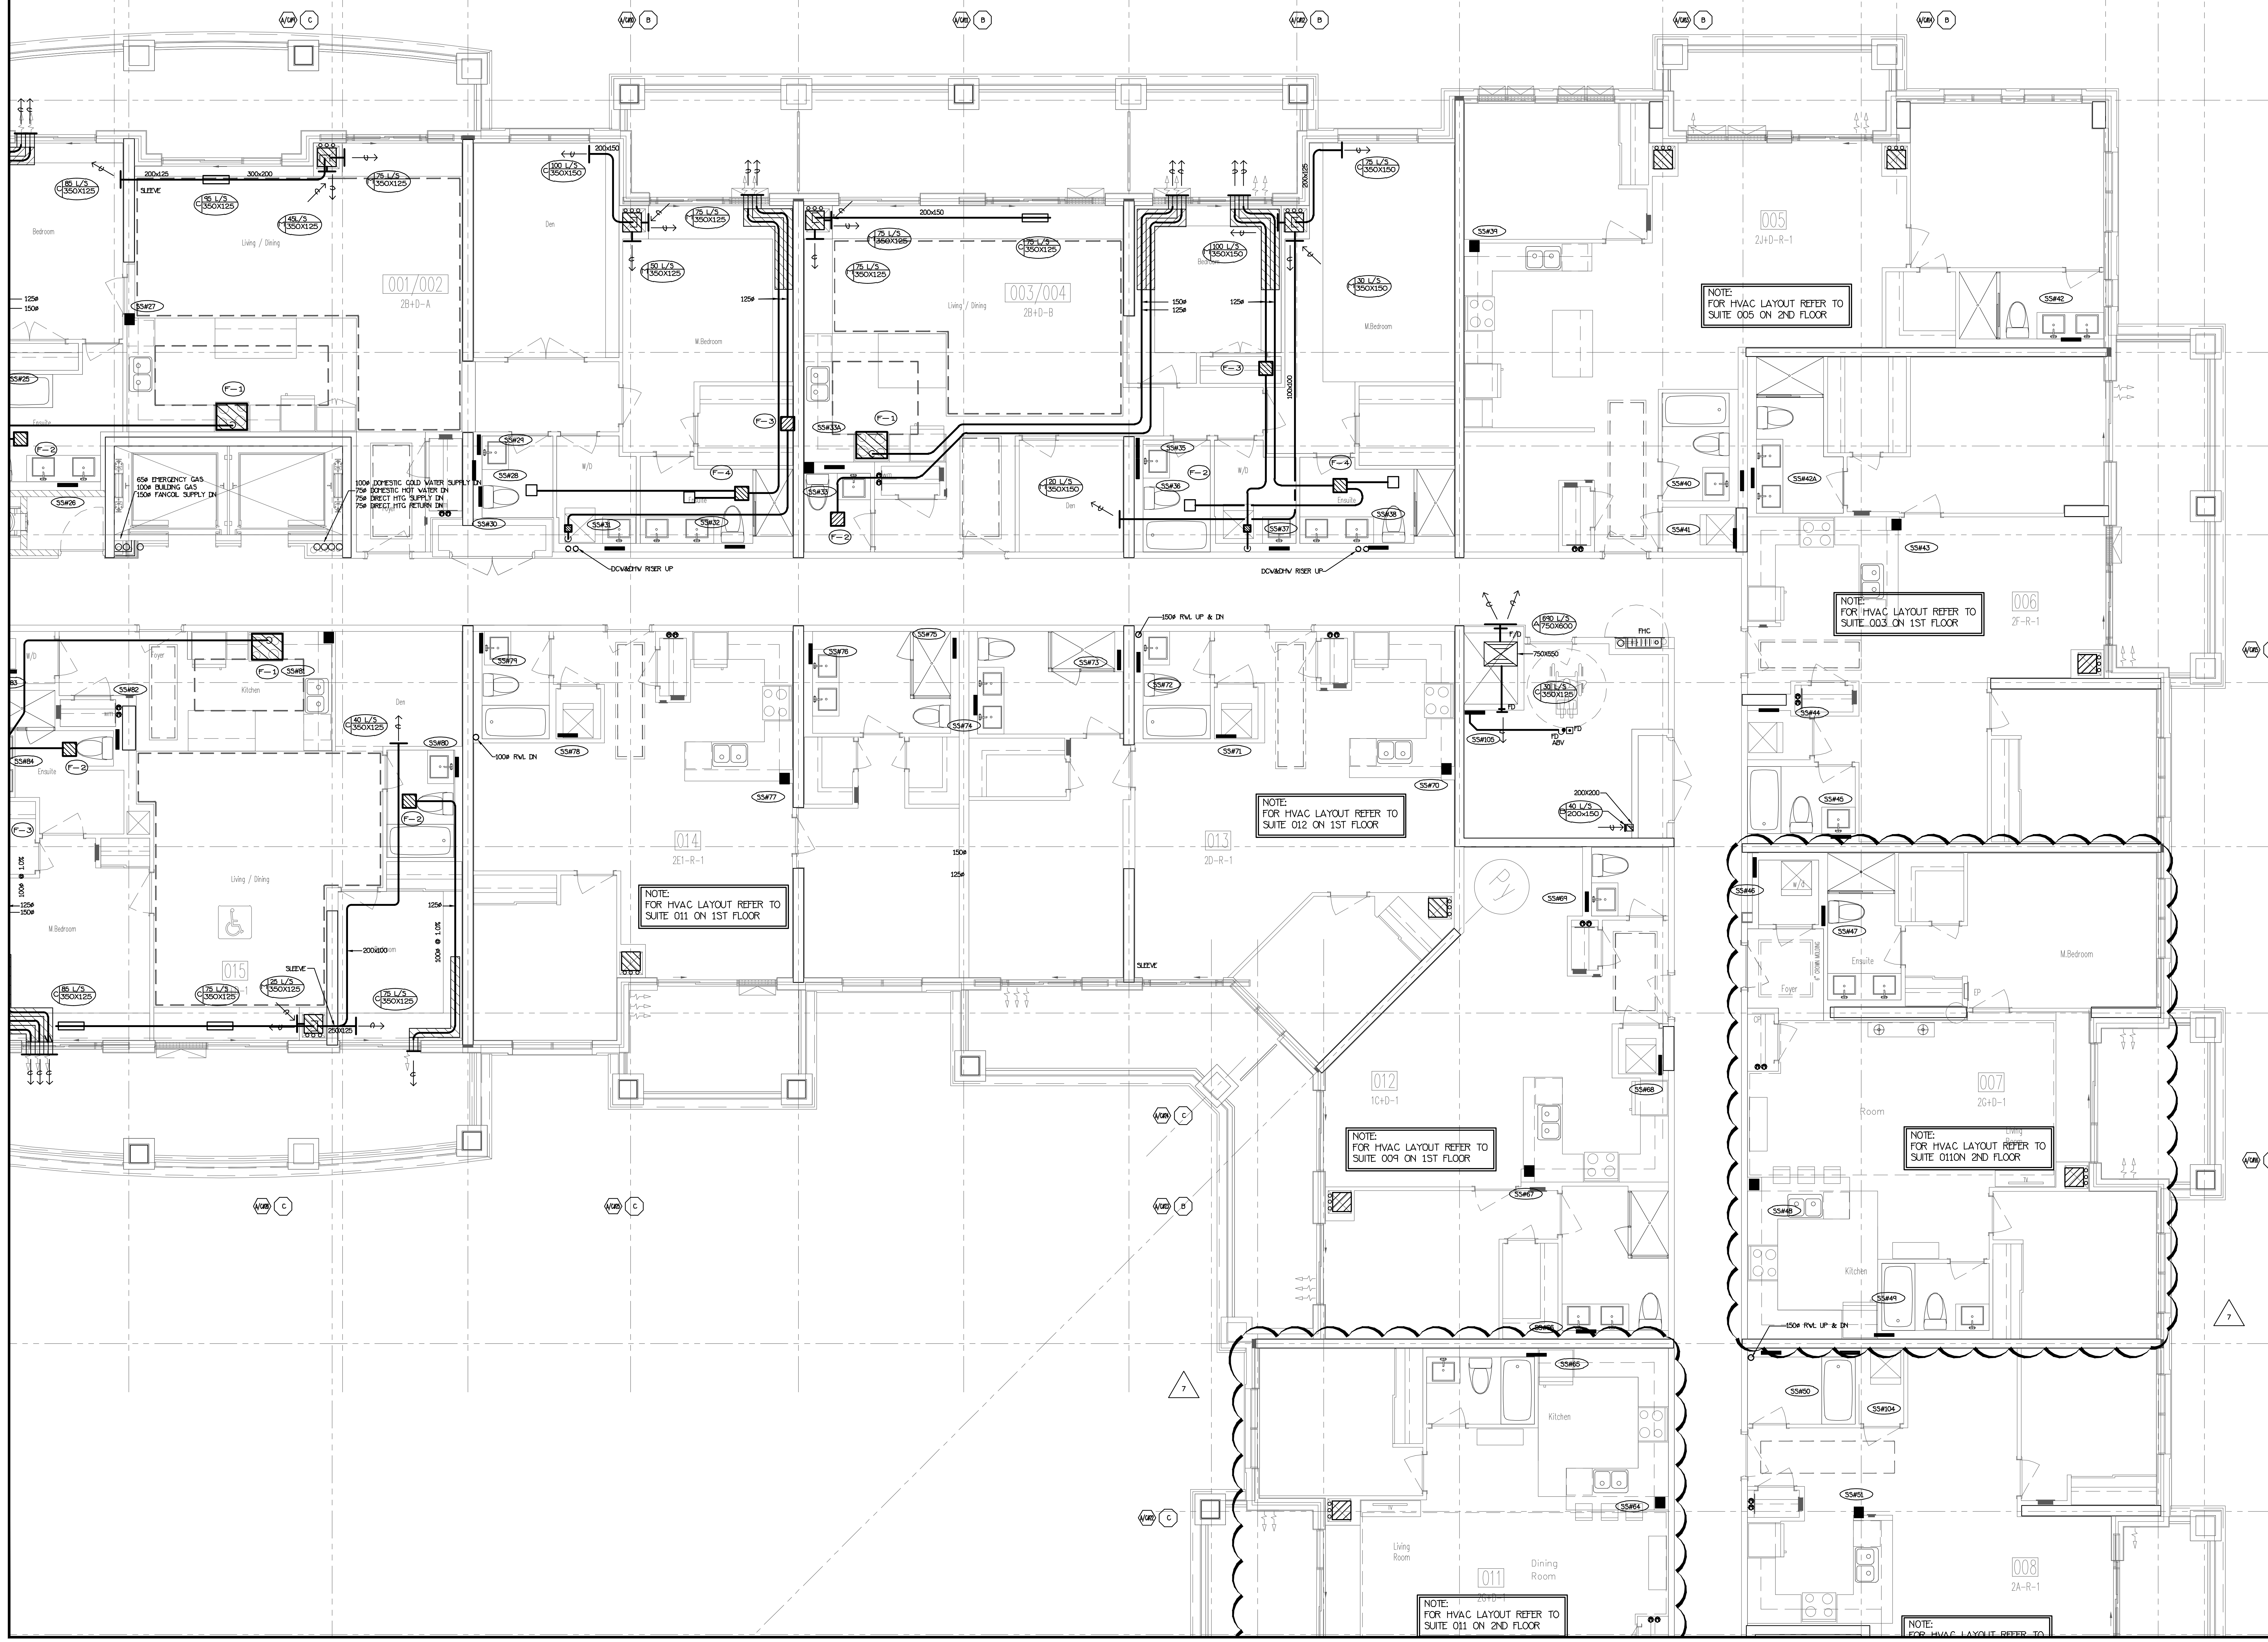
[illegible]

This drawing, is an instrument of service, is provided by and is the property of United Engineering, Inc. The contractor must verify and accept responsibility for all dimensions and conditions on site and must notify United Engineering Inc. of any discrepancy before proceeding.

United Engineering Inc. is not responsible for the accuracy of Architectural, structural, interior design, etc. on this drawing.

Refer to the appropriate trade drawings before proceeding with any work. Installation must conform to all applicable codes and requirements of the authorities having jurisdiction.

This drawing is not to be scaled, all symbols are graphic representations only.

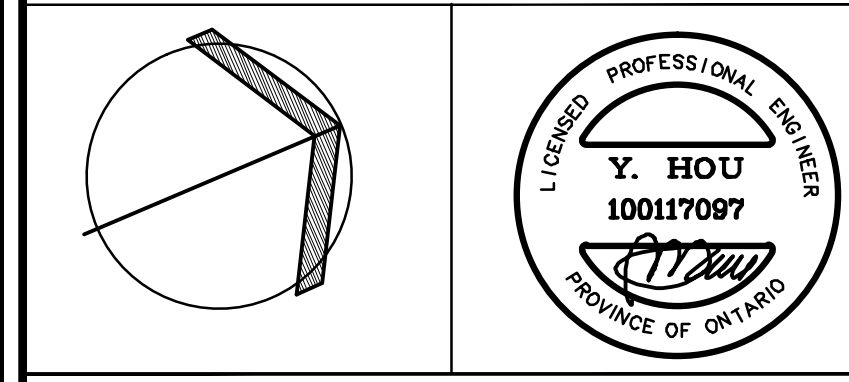

United Engineering Inc.
 Mechanical Electrical Consulting Engineers
 3645 Keele Street, Suite 105,
 Toronto, Ontario, M3J 1M6
 Tel: (416) 398 1999, Fax: (416) 398 1933


TITLE

PART 3RD FLOORS PLAN
MECHANICAL

PROJECT
25 BAKER HILL BLVD.
ROYAL PINE HOMES

STOUFFVILLE, ONTARIO
PROPOSED RESIDENTIAL DEVELOPMENT

DRAWN	CHECKED	SCALE
GC	BT	1:50
DATE	PROJECT	DRAWING
JUNE 2015	14-016	M-18
		OF 42

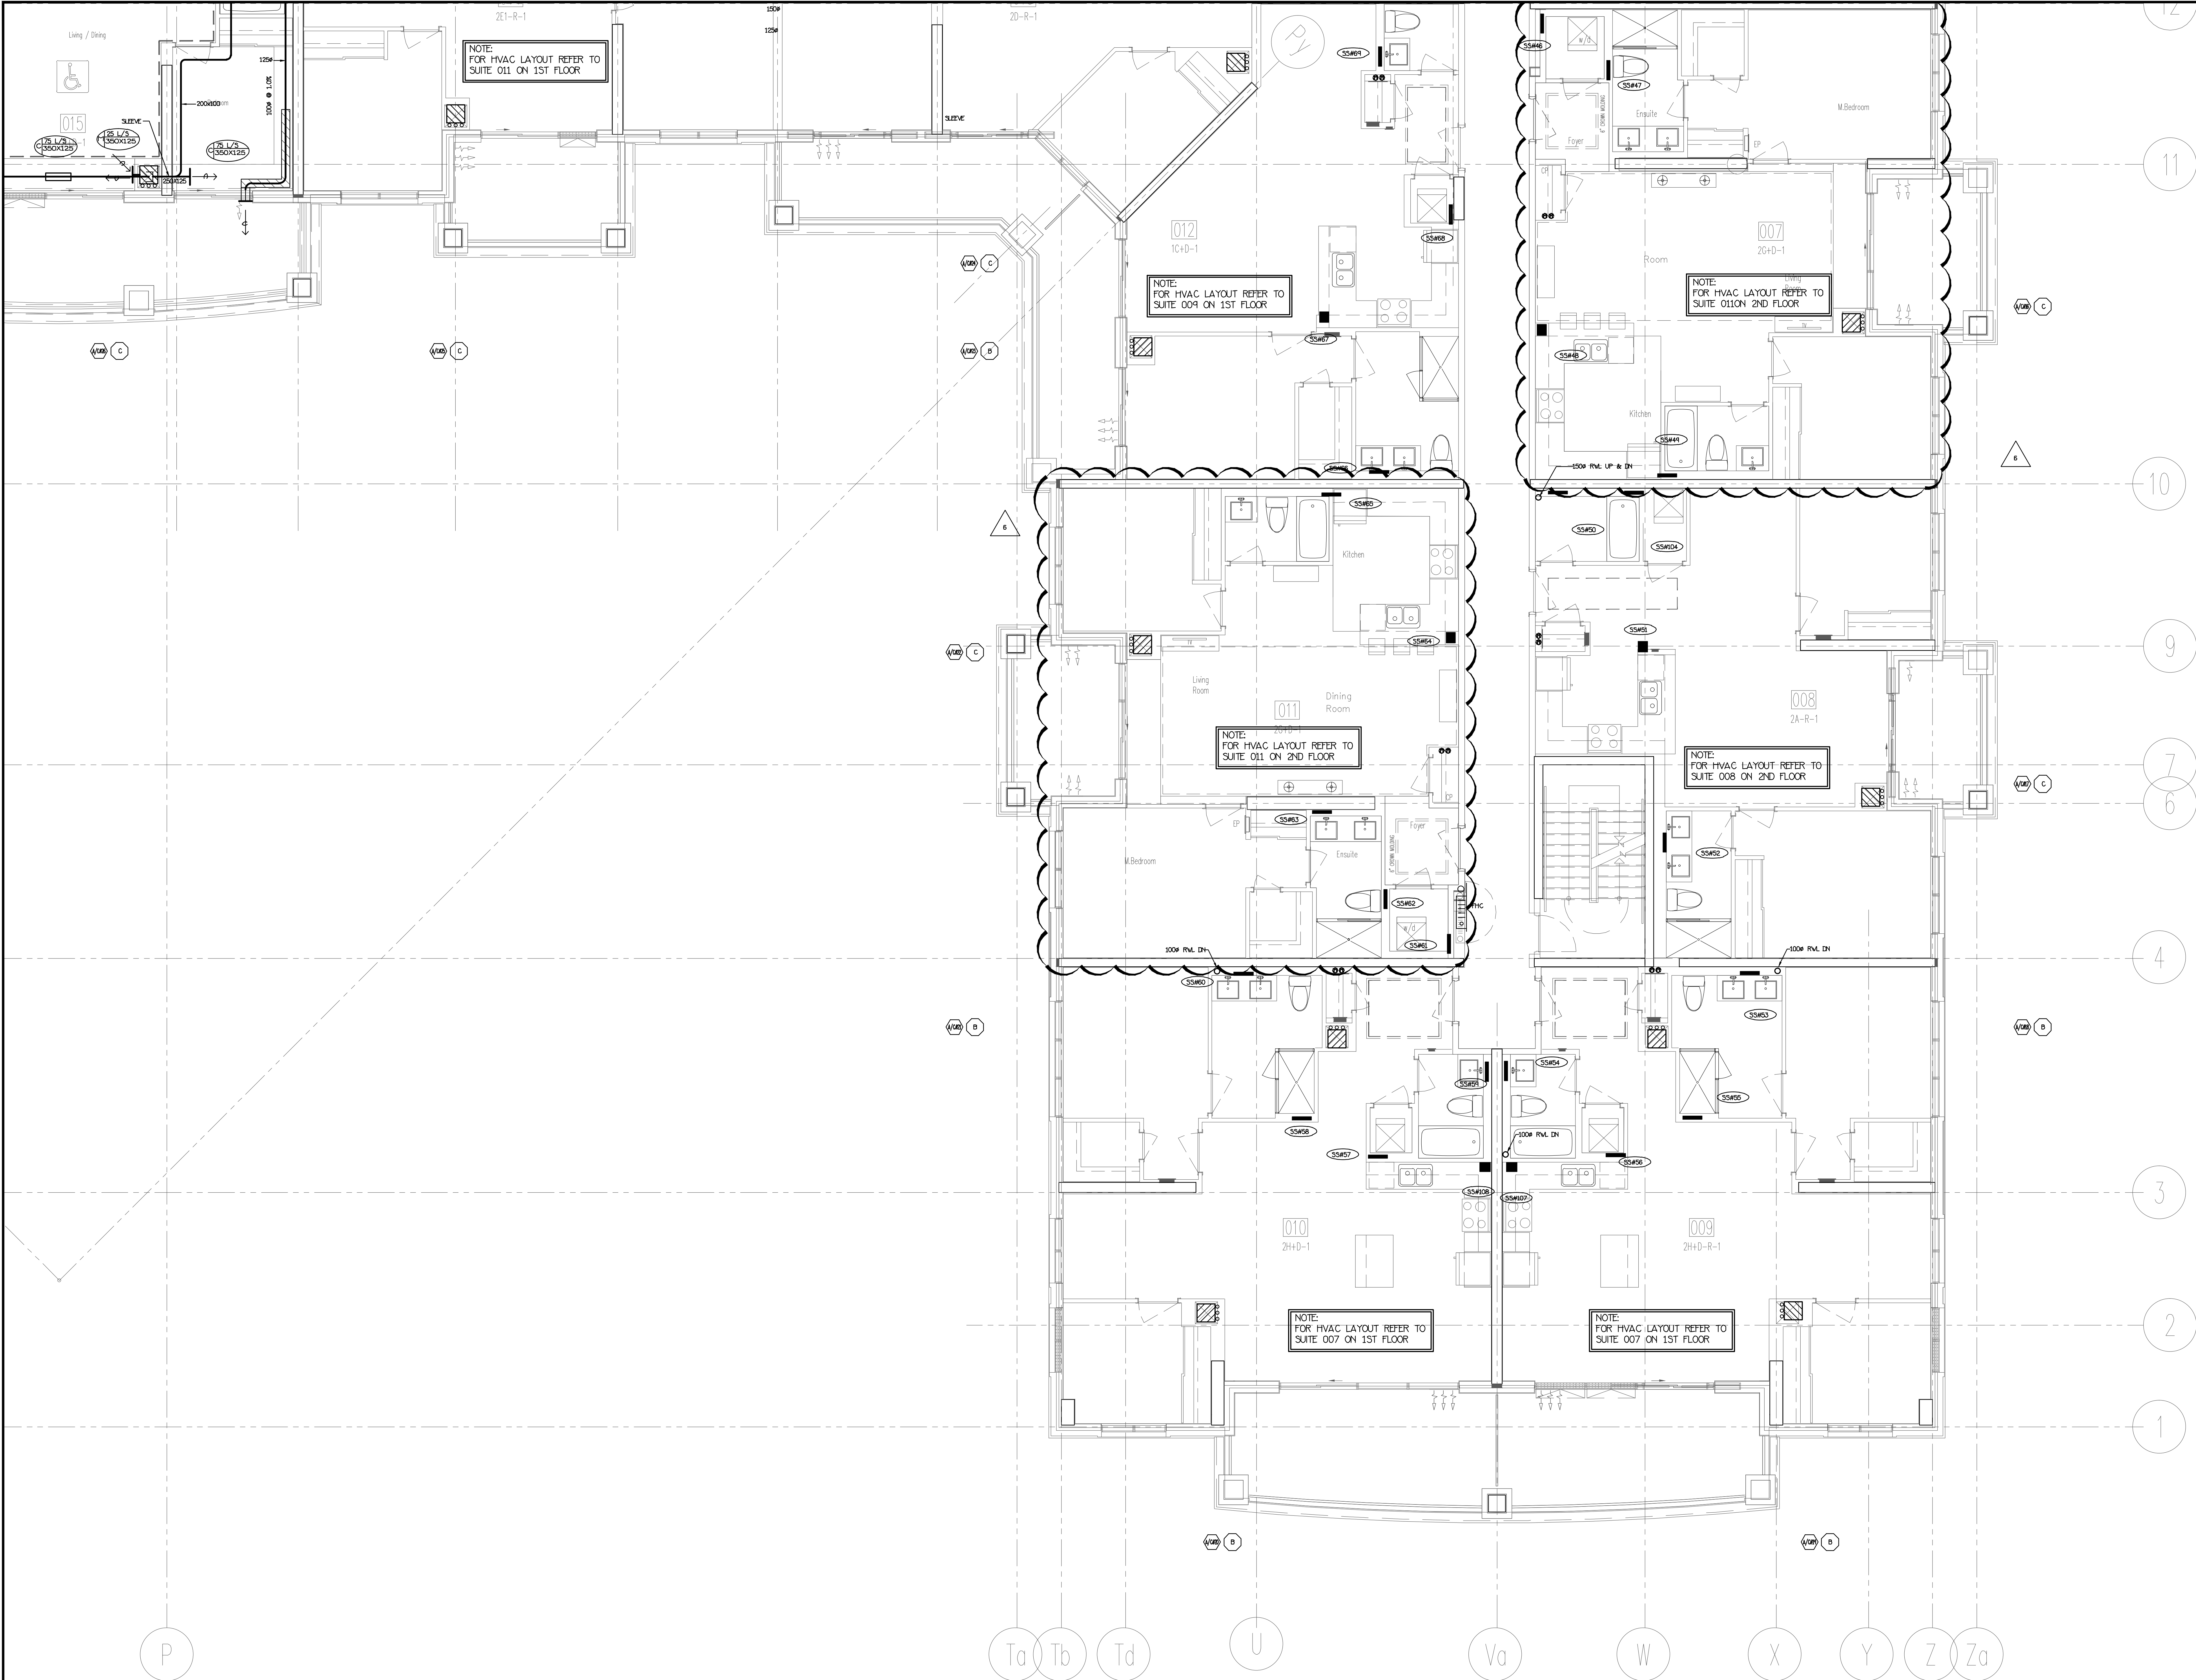

NO.	BY	DESCRIPTION	DATE
6	LB	REVISED AS PER SITE INSTRUCTION 11-14	MAR/14/2018
5	LB	REVISED AS PER SITE INSTRUCTION 11-8	AUG/25/2017
4	LB	REVISED AS PER SITE INSTRUCTION 11-5	AUG/09/2017
3	LB	ISSUED FOR CONSTRUCTION	JUL/18/2017
2	LB	PROGRESS FOR CONSTRUCTION	JUL/18/2017
1	LB	ISSUED FOR PERMIT	DEC/28/2016
1	LB	ISSUED FOR TENDER	MAR/23/2016


REVISIONS

This drawing, is an instrument of service, is provided by and is the property of United Engineering Inc. The contractor must verify and accept responsibility for all dimensions and conditions on site and must notify United Engineering Inc. of any discrepancy before proceeding.

United Engineering Inc. is not responsible for the accuracy of Architectural, structural, interior design, etc. on this drawing.


Refer to the appropriate trade drawings before proceeding with any work. Installation must conform to all applicable codes and requirements of the authorities having jurisdiction.

This drawing is not to be scaled, all symbols are graphic representations only.

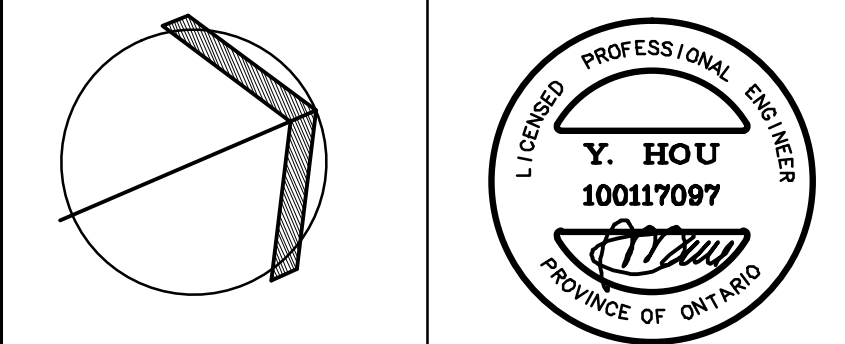

United Engineering Inc.
Mechanical Electrical Consulting Engineers
3045 Keele Street, Suite 105,
Toronto, Ontario, M3J 1W6
Tel: (416) 398 1999, Fax: (416) 398 1933

TITLE PART 3RD FLOORS PLAN MECHANICAL			
PROJECT 25 BAKER HILL BLVD. ROYAL PINE HOMES			
STOUFFVILLE, ONTARIO PROPOSED RESIDENTIAL DEVELOPMENT			
DRAWN GC	CHECKED BT	SCALE 1:50	DRAWING M-19 OF 42
DATE JUNE 2015	PROJECT 14-016		

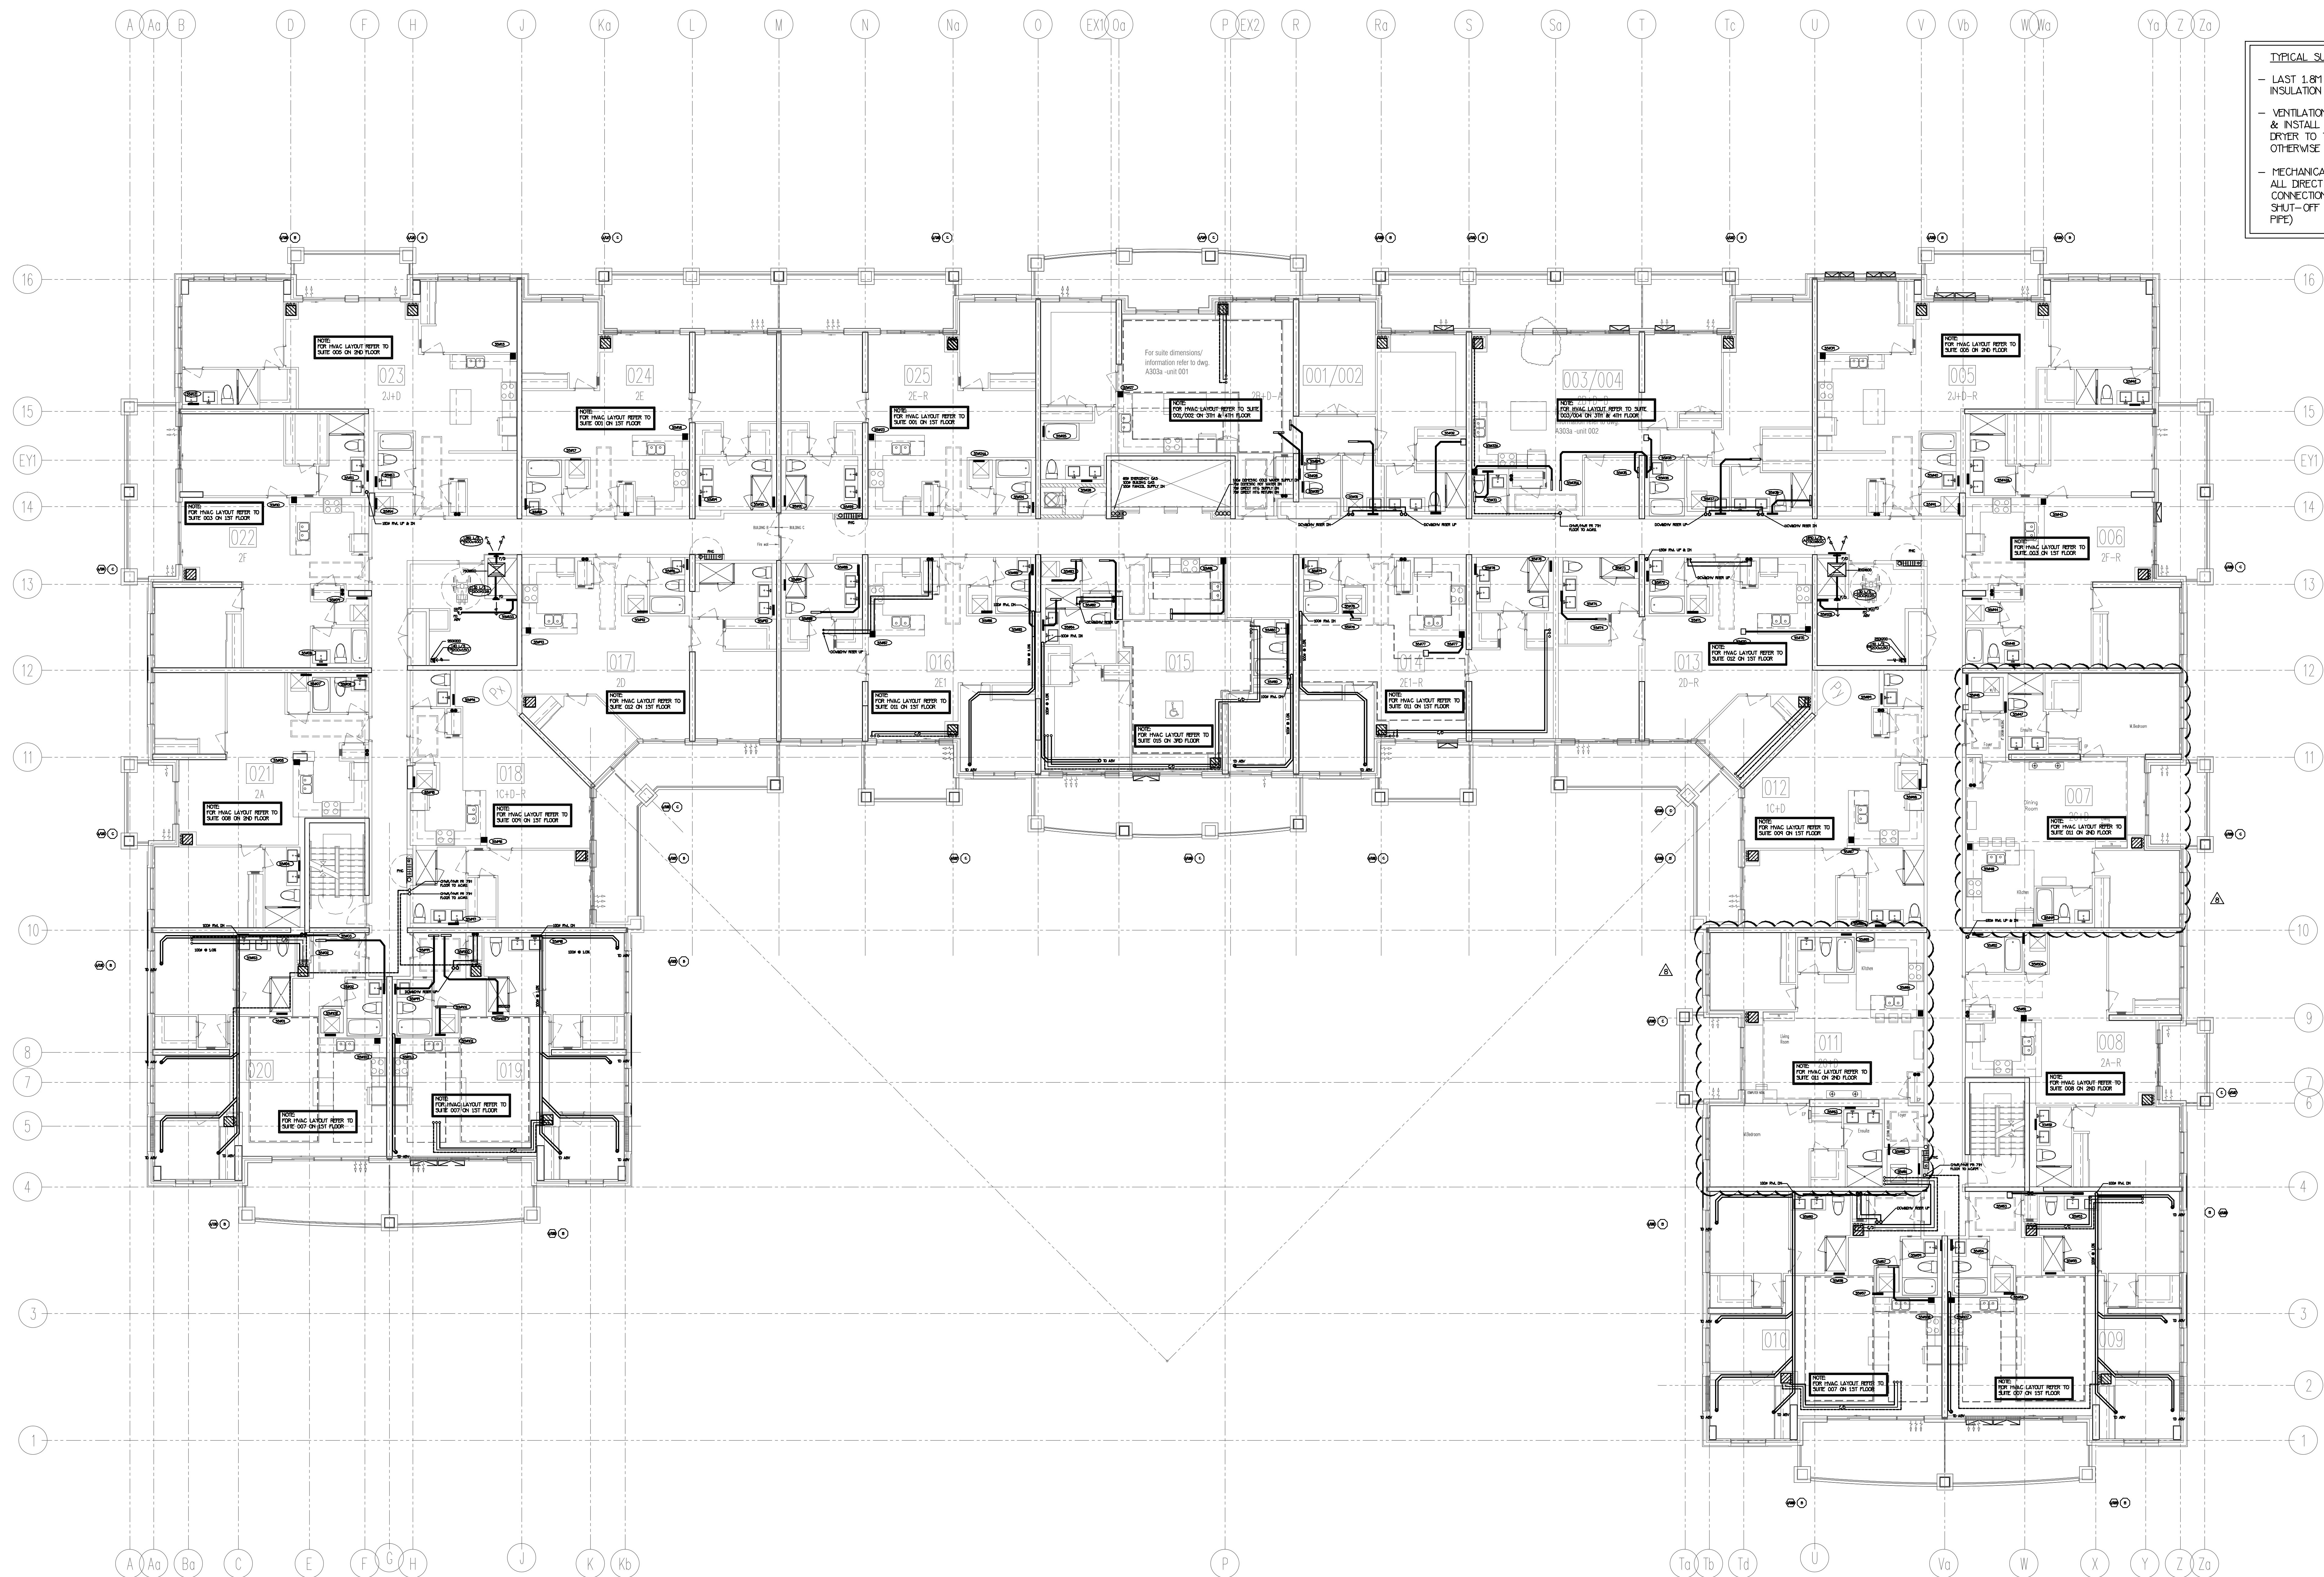


TYPICAL SUITE NOTES:

- LAST 1.8M OF EXHAUST DUCTWORK, C/V INSULATION & VAPOUR BARRIER (TYPICAL)
- VENTILATION CONTRACTOR SHALL SUPPLY & INSTALL THE FLEXIBLE DRYER HOSE FROM DRYER TO THE RIGID EXHAUST DUCT UNLESS OTHERWISE NOTED BY OWNER
- MECHANICAL CONTRACTOR SHALL MAKE ALL DIRECT PLUMBING & DRAINAGE CONNECTIONS TO THE DISHWASHER (C/W SHUT-OFF VALVE & COPPER SUPPLY PIPE)

NOTE: FULLY SPRINKLERED BUILDING FOR FIRE PROTECTION DESIGN PLEASE REFER TO DISANO SPRINKLER DESIGN UNITED DRAWINGS.


NO.	BY	DESCRIPTION	DATE
8	LB	REVISED AS PER SITE INSTRUCTION H-14	MAR/14/2018
7	LB	REVISED AS PER SITE INSTRUCTION H-10	OCT/31/2017
6	LB	REVISED AS PER SITE INSTRUCTION H-6	AUG/25/2017
5	LB	REVISED AS PER SITE INSTRUCTION H-5 ISSUED FOR CONSTRUCTION	AUG/09/2017
4	LB	PROGRESS FOR CONSTRUCTION	JUL/18/2017
3	LB	REVISED AS PER SITE INSTRUCTION H-4	MAY/16/2017
2	LM	ISSUED FOR PERMIT	JCC/28/2016
1	LM	ISSUED FOR TENDER	MAR/23/2016

This drawing, is an instrument of service, is provided by and is the property of United Engineering Inc. The contractor must verify and accept responsibility for all dimensions and conditions on site and must notify United Engineering Inc. of any discrepancy before proceeding. United Engineering Inc. is not responsible for the accuracy of Architectural, structural, interior design, etc. on this drawing. Refer to the appropriate trade drawings before proceeding with any work. Installation must conform to all applicable codes and requirements of the authorities having jurisdiction. This drawing is not to be scaled, all symbols are graphic representations only.

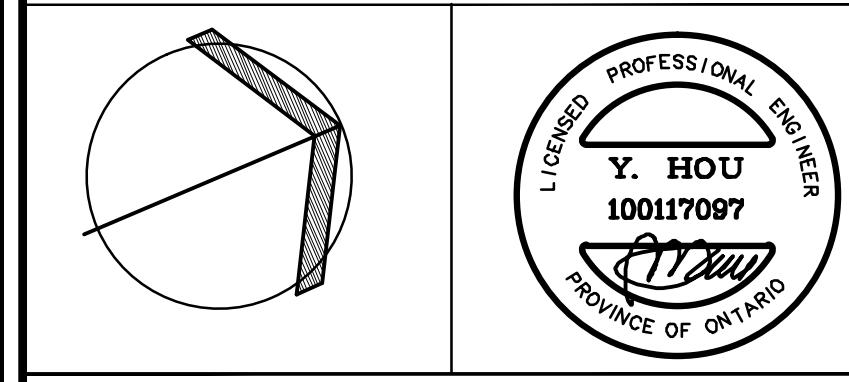

United Engineering Inc.
Mechanical Electrical Consulting Engineers
3045 Keele Street, Suite 105,
Toronto, Ontario, M3J 1M6
Tel: (416) 398 1999, Fax: (416) 398 1933

TITLE PART 5TH FLOORS PLAN MECHANICAL			
PROJECT 25 BAKER HILL BLVD. ROYAL PINE HOMES			
STOUFFVILLE, ONTARIO PROPOSED RESIDENTIAL DEVELOPMENT			
DRAWN GC	CHECKED BT	SCALE 1:100	
DATE JUNE 2015	PROJECT 14-016	DRAWING M-20	OF 42

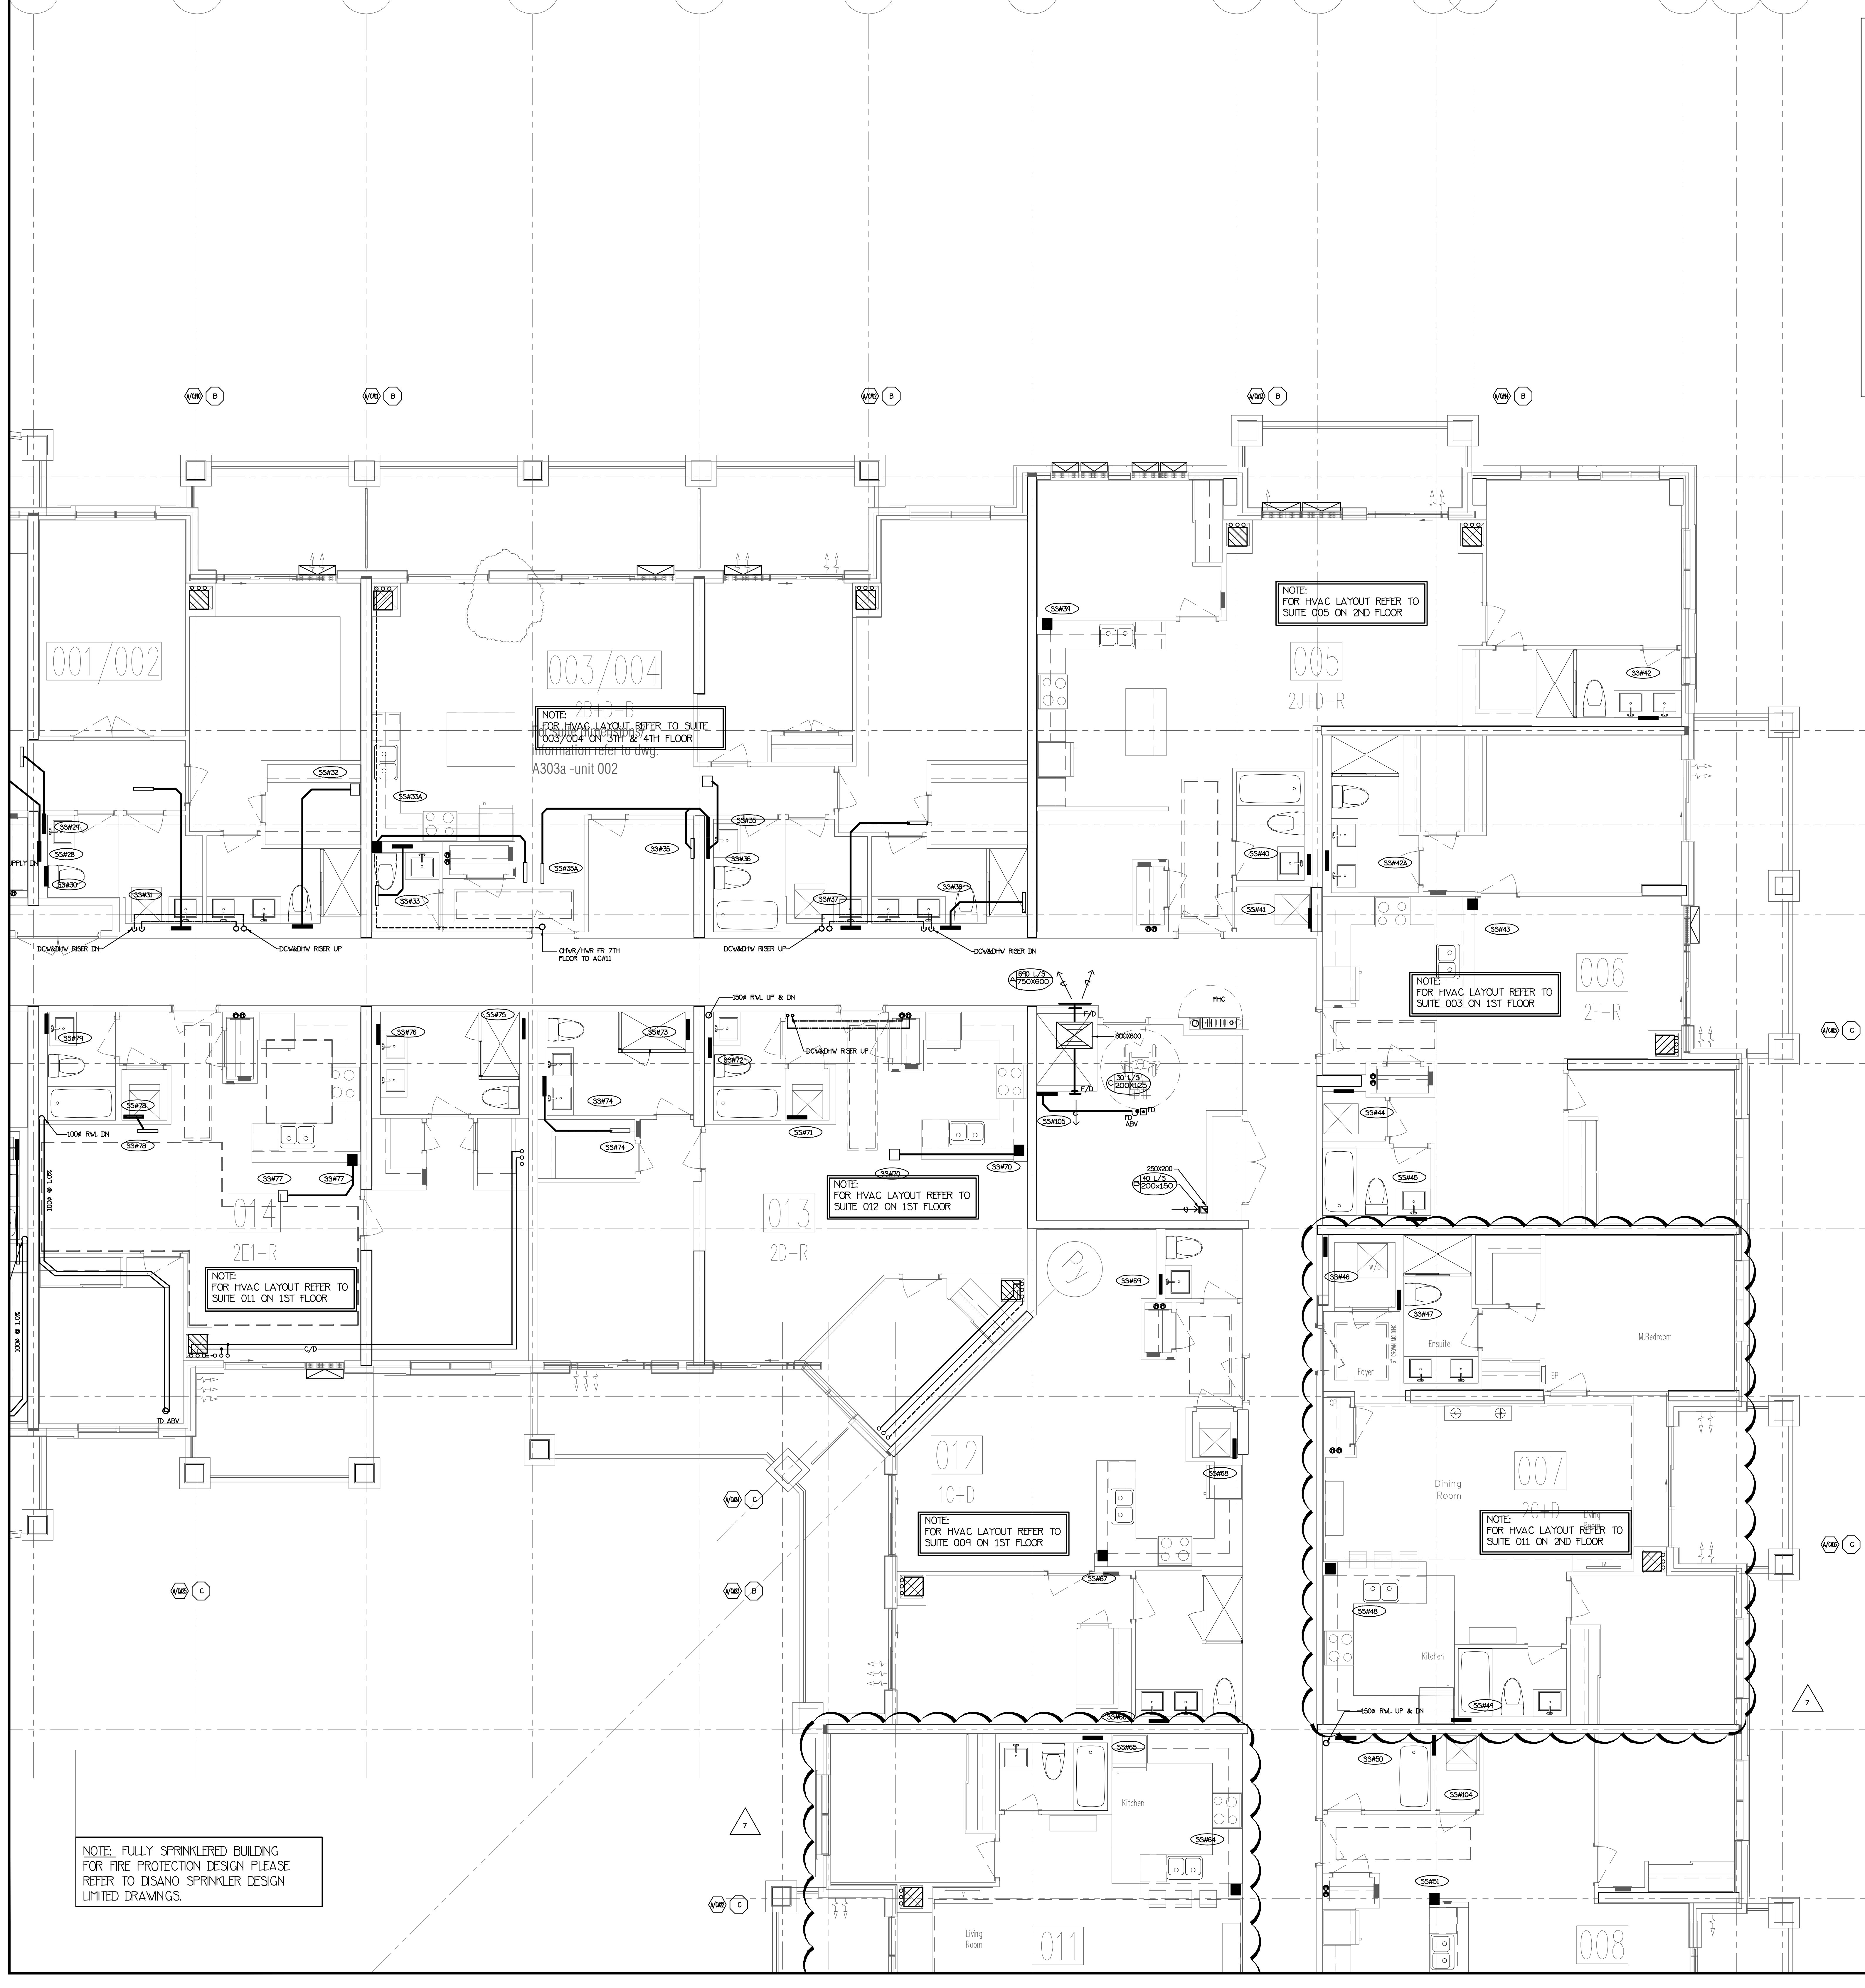


TYPICAL SUITE NOTES:

- LAST 1.8M OF EXHAUST DUCTWORK C/W INSULATION & VAPOUR BARRIER (TYPICAL)
- VENTILATION CONTRACTOR SHALL SUPPLY & INSTALL THE FLEXIBLE DRYER HOSE FROM DRYER TO THE RIGID EXHAUST DUCT UNLESS OTHERWISE NOTED BY OWNER
- MECHANICAL CONTRACTOR SHALL MAKE ALL DIRECT PLUMBING & DRAINAGE CONNECTIONS TO THE DISHWASHER (C/W SHUT-OFF VALVE & COPPER SUPPLY PIPE)

REVISIONS		
NO.	BY	DESCRIPTION
7	LB	REVISED AS PER SITE INSTRUCTION H-14
6	LB	REVISED AS PER SITE INSTRUCTION H-5
5	LB	REVISED AS PER SITE INSTRUCTION H-5
4	LB	PROGRESS FOR CONSTRUCTION
3	LB	ISSUED AS PER SITE INSTRUCTION H-4
2	LM	ISSUED FOR PERMIT
1	LM	ISSUED FOR TENDER
DATE		

This drawing, is an instrument of service, is provided by and is the property of United Engineering Inc. The contractor must verify and accept responsibility for all dimensions and conditions on site and must notify United Engineering Inc. of any discrepancy before proceeding. United Engineering Inc. is not responsible for the accuracy of Architectural, structural, interior design, etc. on this drawing. Refer to the appropriate trade drawings before proceeding with any work. Installation must conform to all applicable codes and requirements of the authorities having jurisdiction. This drawing is not to be scaled, all symbols are graphic representations only.

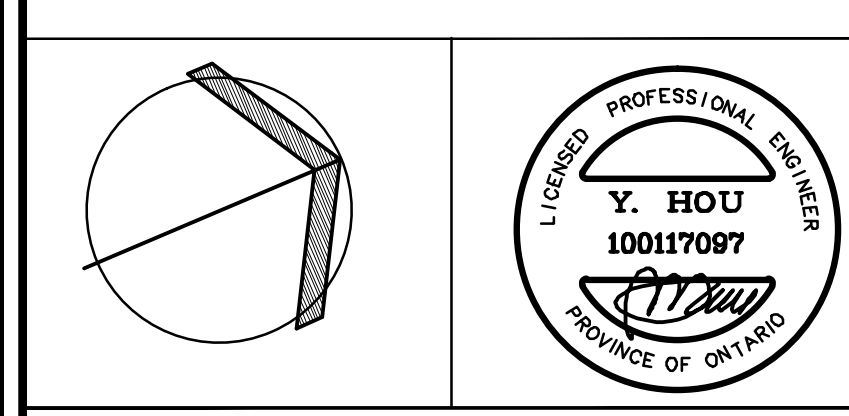

United Engineering Inc.
Mechanical Electrical Consulting Engineers
3045 Keele Street, Suite 105,
Toronto, Ontario, M3J 1M6
Tel: (416) 308 1999, Fax: (416) 308 1933

TITLE			
PART 5TH FLOORS PLAN MECHANICAL			
PROJECT			
25 BAKER HILL BLVD. ROYAL PINE HOMES			
STOUFFVILLE, ONTARIO			
PROPOSED RESIDENTIAL DEVELOPMENT			
DRAWN	GC	CHECKED	BT
DATE	JUNE 2015	PROJECT	14-016
		SCALE	1:50
		DRAWING	M-23
		OF	42




This drawing, is an instrument of service, is provided by and is the property of United Engineering Inc. The contractor must verify and accept responsibility for all dimensions and conditions on site and must notify United Engineering Inc. of any discrepancy before proceeding.

United Engineering Inc. is not responsible for the accuracy of Architectural, structural, interior design, etc. on this drawing.

Refer to the appropriate trade drawings before proceeding with any work. Installation must conform to applicable codes and requirements of the authorities having jurisdiction.

This drawing is not to be scaled, all symbols are graphic representations only.

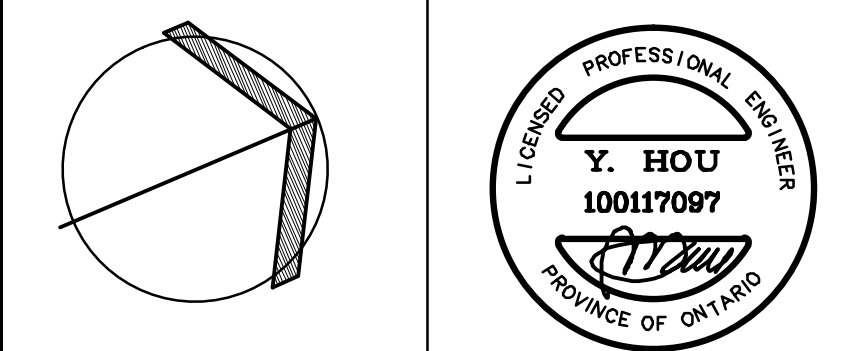

United Engineering Inc.
 Mechanical Electrical Consulting Engineers
 3645 Keele Street, Suite 105,
 Toronto, Ontario, M3J 1M6
 Tel: (416) 398 1999, fax: (416) 398 1933

TITLE


**PART 5TH FLOORS PLAN
MECHANICAL**

PROJECT
25 BAKER HILL BLVD.
ROYAL PINE HOMES

STOUFFVILLE, ONTARIO

DRAWN GC	CHECKED BT	SCALE 1:50
-------------	---------------	---------------

DATE	PROJECT	DRAWING
JUNE 2015	14-016	M-24
		OF 42

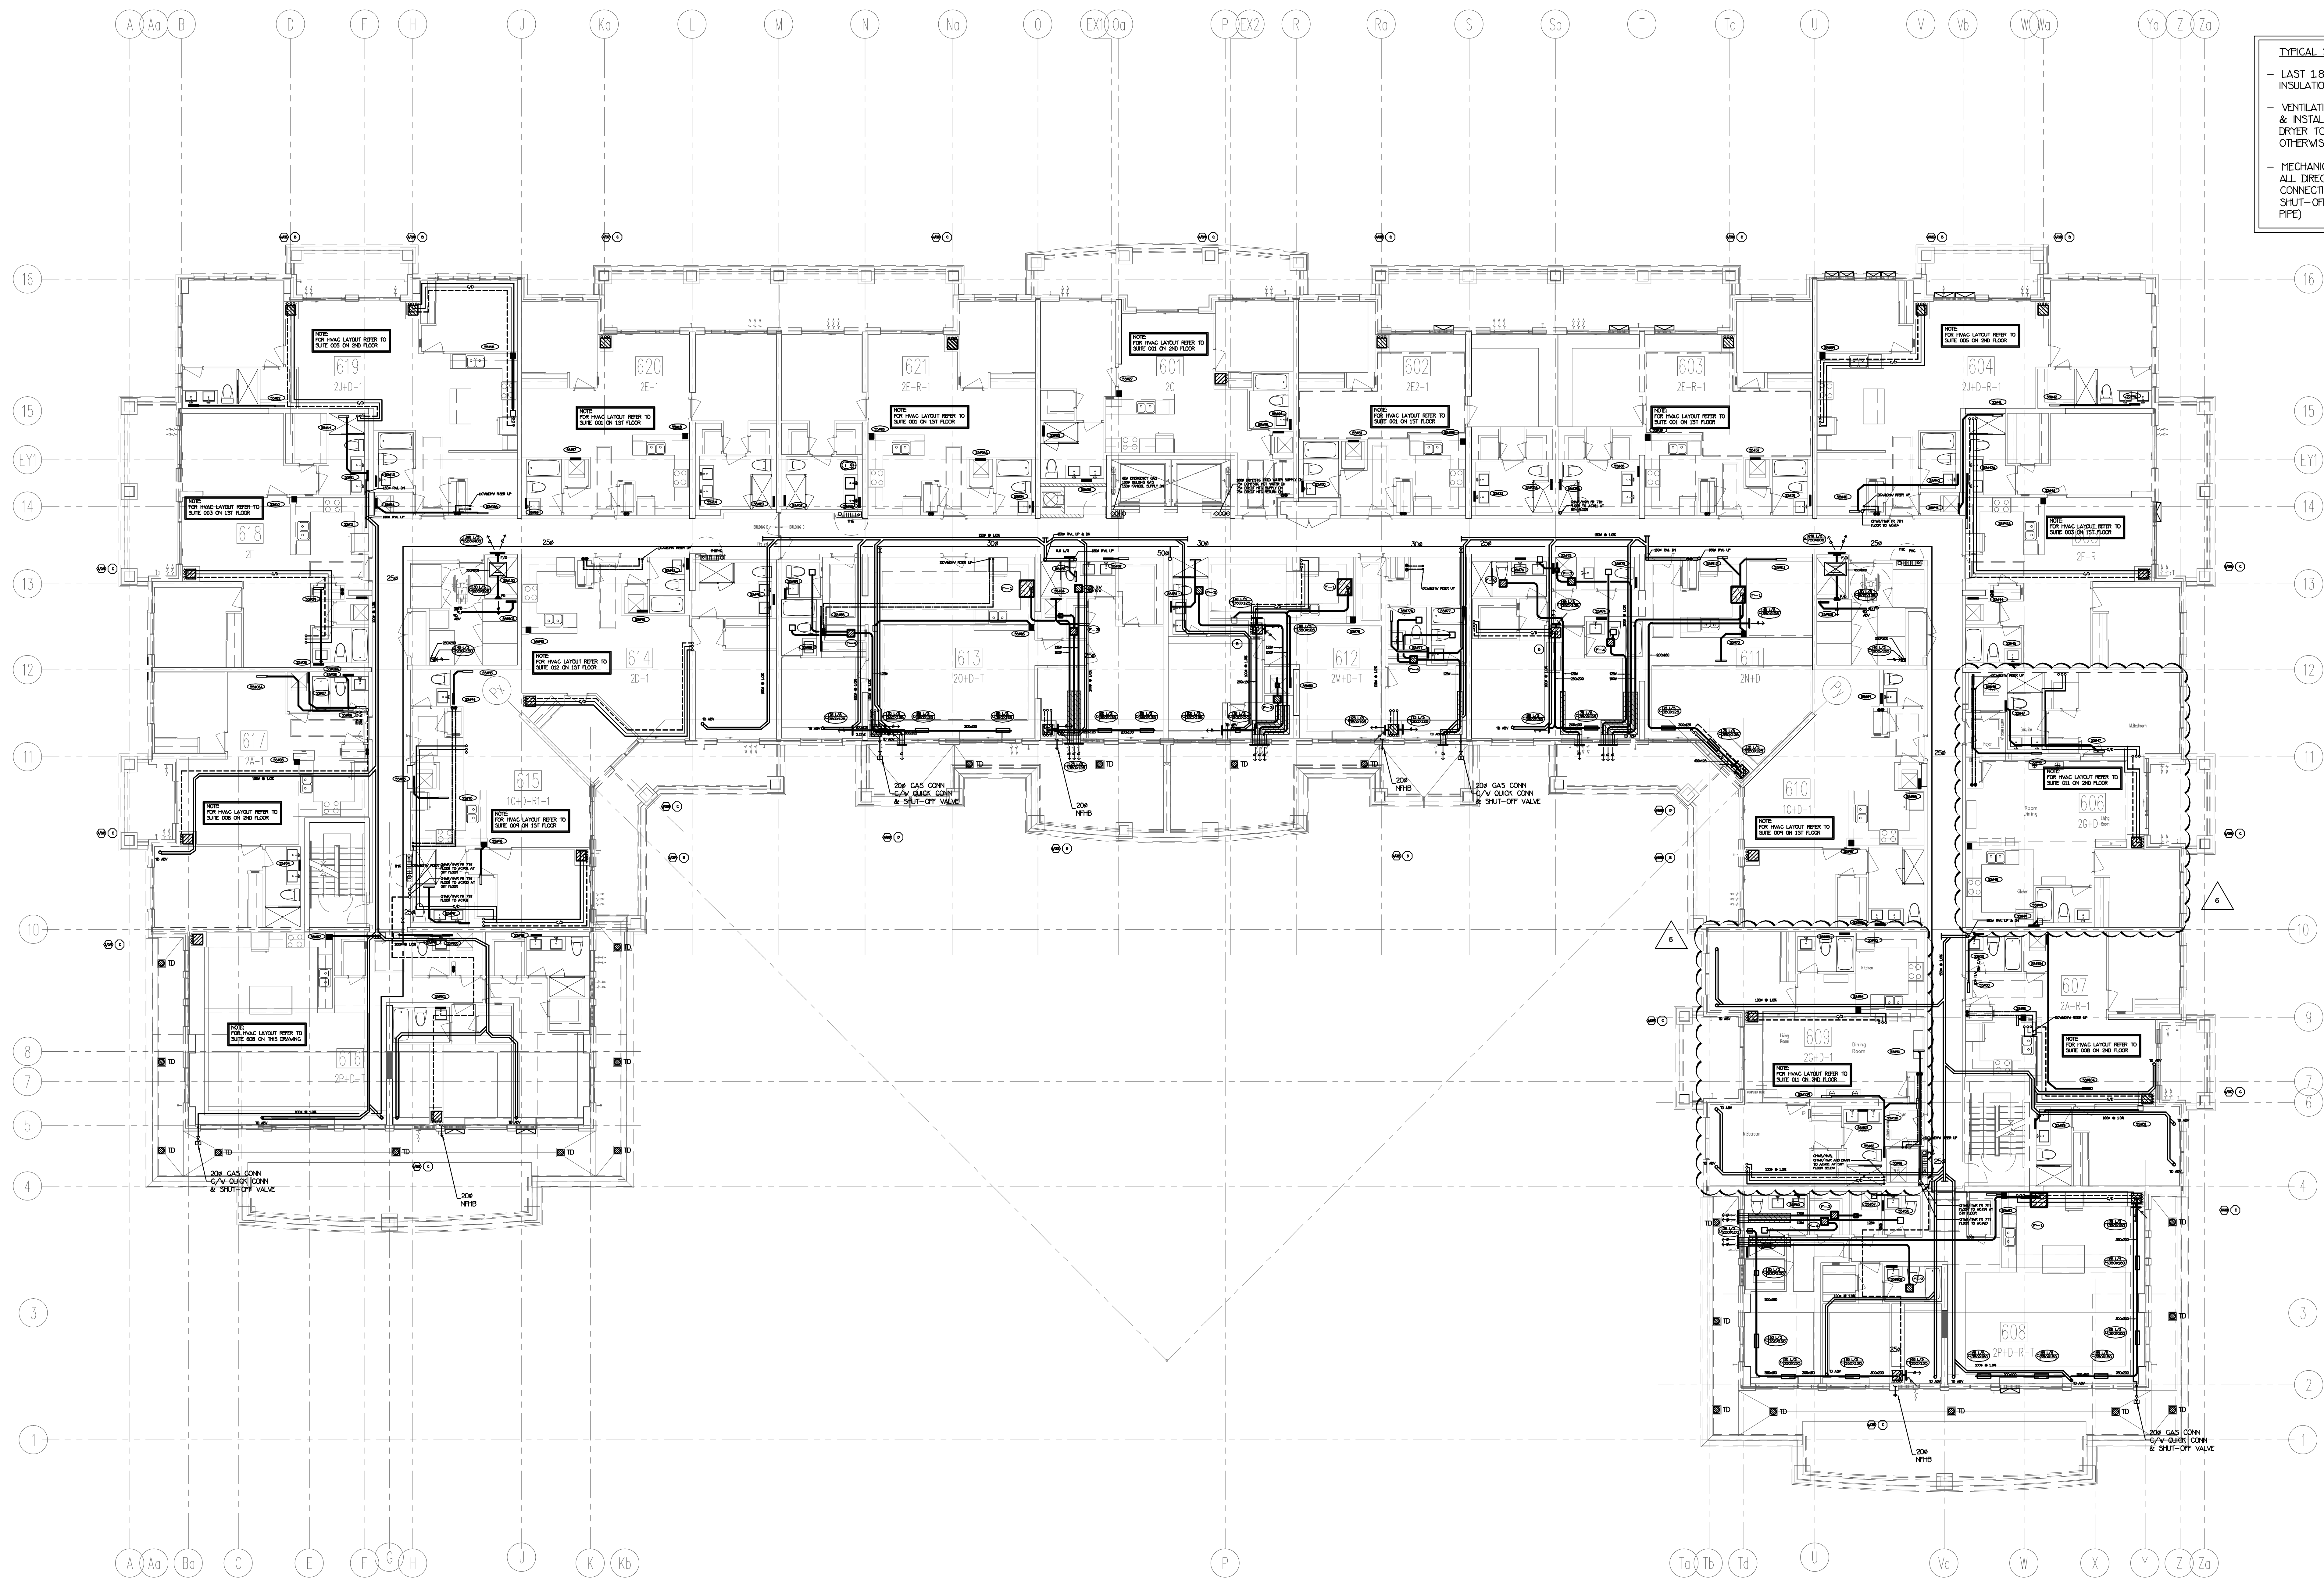


TYPICAL SUITE NOTES:

- LAST 1.8M OF EXHAUST DUCTWORK C/V INSULATION & VAPOUR BARRIER (TYPICAL)
- VENTILATION CONTRACTOR SHALL SUPPLY & INSTALL THE FLEXIBLE DRYER HOSE FROM DRYER TO THE RIGID EXHAUST DUCT UNLESS OTHERWISE NOTED BY OWNER
- MECHANICAL CONTRACTOR SHALL MAKE ALL DIRECT PLUMBING & DRAINAGE CONNECTIONS TO THE DISHWASHER (C/V SHUT-OFF VALVE & COPPER SUPPLY PIPE)

NOTE: FULLY SPRINKLERED BUILDING FOR FIRE PROTECTION DESIGN PLEASE REFER TO DISANO SPRINKLER DESIGN UNITED DRAWINGS.

NO.	BY	DESCRIPTION	DATE
6	LB	REVISED AS PER SITE INSTRUCTION 11-14	MAR/14/2018
5	LB	REVISED AS PER SITE INSTRUCTION 11-10	OCT/31/2017
4	LD	REVISED AS PER SITE INSTRUCTION 11-5 ISSUED FOR CONSTRUCTION	AUG/09/2017
3	LD	PROGRESS FOR CONSTRUCTION	JUL/18/2017
2	LD	ISSUED FOR PERMIT	DEC/28/2016
1	LD	ISSUED FOR TENDER	MAR/23/2016

This drawing, is an instrument of service, is provided by and is the property of United Engineering Inc. The contractor must verify and accept responsibility for all dimensions and conditions on site and must notify United Engineering Inc. of any discrepancy before proceeding. United Engineering Inc. is not responsible for the accuracy of Architectural, structural, interior design, etc. on this drawing. Refer to the appropriate trade drawings before proceeding with any work. Installation must conform to all applicable codes and requirements of the authorities having jurisdiction. This drawing is not to be scaled, all symbols are graphic representations only.

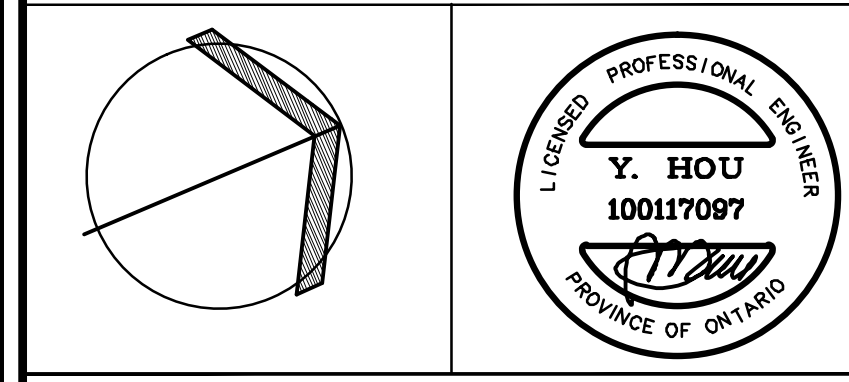

United Engineering Inc.
Mechanical Electrical Consulting Engineers
3045 Keele Street, Suite 105,
Toronto, Ontario, M3J 1M6
Tel: (416) 398 1999, Fax: (416) 398 1933

TITLE			
PART 6TH FLOORS PLAN MECHANICAL			
PROJECT			
25 BAKER HILL BLVD. ROYAL PINE HOMES			
STOUFFVILLE, ONTARIO		PROPOSED RESIDENTIAL DEVELOPMENT	
DRAWN	GC	CHECKED	ST
DATE	PROJECT	SCALE	DRAWING
JUNE 2015	14-016	1:100	M-25
			OF 42

TYPICAL SUITE NOTES:

- LAST 1.8M OF EXHAUST DUCTWORK C/W INSULATION & VAPOUR BARRIER (TYPICAL)
- VENTILATION CONTRACTOR SHALL SUPPLY & INSTALL THE FLEXIBLE DRYER HOSE FROM DRYER TO THE RIGID EXHAUST DUCT UNLESS OTHERWISE NOTED BY OWNER
- MECHANICAL CONTRACTOR SHALL MAKE ALL DIRECT PLUMBING & DRAINAGE CONNECTIONS TO THE DISHWASHER (C/W SHUT-OFF VALVE & COPPER SUPPLY PIPE)




This drawing, is an instrument of service, is provided by and is the property of United Engineering Inc. The contractor must verify and accept responsibility for all dimensions and conditions on site and must notify United Engineering Inc. of any discrepancy before proceeding.

United Engineering Inc. is not responsible for the accuracy of Architectural, structural, interior design, etc. on this drawing.

Refer to the appropriate trade drawings before proceeding with any work. Installation must conform to all applicable codes and requirements of the authorities having jurisdiction.

This drawing is not to be scaled, all symbols are graphic representations only.

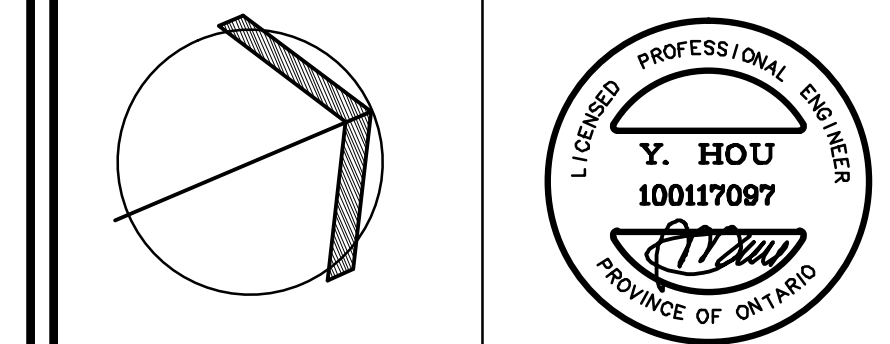

TITLE


PART 6TH FLOORS PLAN
MECHANICAL

STOUFFVILLE, ONTARIO
PROPOSED RESIDENTIAL DEVELOPMENT

DRAWN GC	CHECKED BT	SCALE 1:50
DATE JUNE 2015	PROJECT 14-016	DRAWING M-28 OF 42



This drawing, is an instrument of service, is provided by and is the property of United Engineering Inc. The contractor must verify and accept responsibility for all dimensions and conditions on site and must notify United Engineering Inc. of any discrepancy before proceeding. United Engineering Inc. is not responsible for the accuracy of Architectural, structural, interior design, etc. on this drawing. Refer to the appropriate trade drawings before proceeding with any work. Installation must conform to applicable codes and requirements of the authorities having jurisdiction. This drawing is not to be scaled, all symbols are graphic representations only.

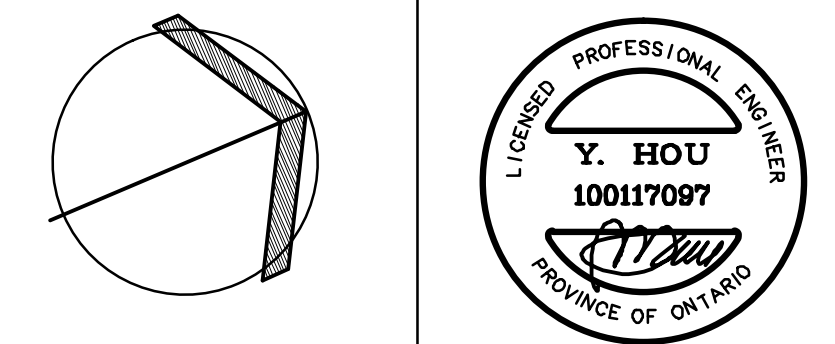

United Engineering Inc.
 Mechanical Electrical Consulting Engineers
 3645 Keele Street, Suite 105,
 Toronto, Ontario, M3J 1M6
 Tel: (416) 398 1999, Fax: (416) 398 1933

TITLE

**PART 6TH FLOORS PLAN
MECHANICAL**

PROJECT
25 BAKER HILL BLVD.
ROYAL PINE HOMES

STOUFFVILLE, ONTARIO
PROPOSED RESIDENTIAL DEVELOPMENT

DRAWN GC	CHECKED BT	SCALE 1:50
DATE JUNE 2015	PROJECT 14-016	DRAWING M-29 OF 42